

LIFT STATIONS 3-3 & 15-1 REPLACEMENTS


PINEHURST, NORTH CAROLINA

MAY 2024

NOTES

- 1) INSTALLATION SHALL BE COORDINATED WITH MCPU.
- 2) SUBMITTALS SHALL BE APPROVED BEFORE CONSTRUCTION BEGINS.
- 3) FOLLOW MOORE COUNTY SPECIFICATIONS FOUND ON THE WEB SITE AT:
<https://www.moorecountync.gov/public-works/engineering>



PROJECT AREA

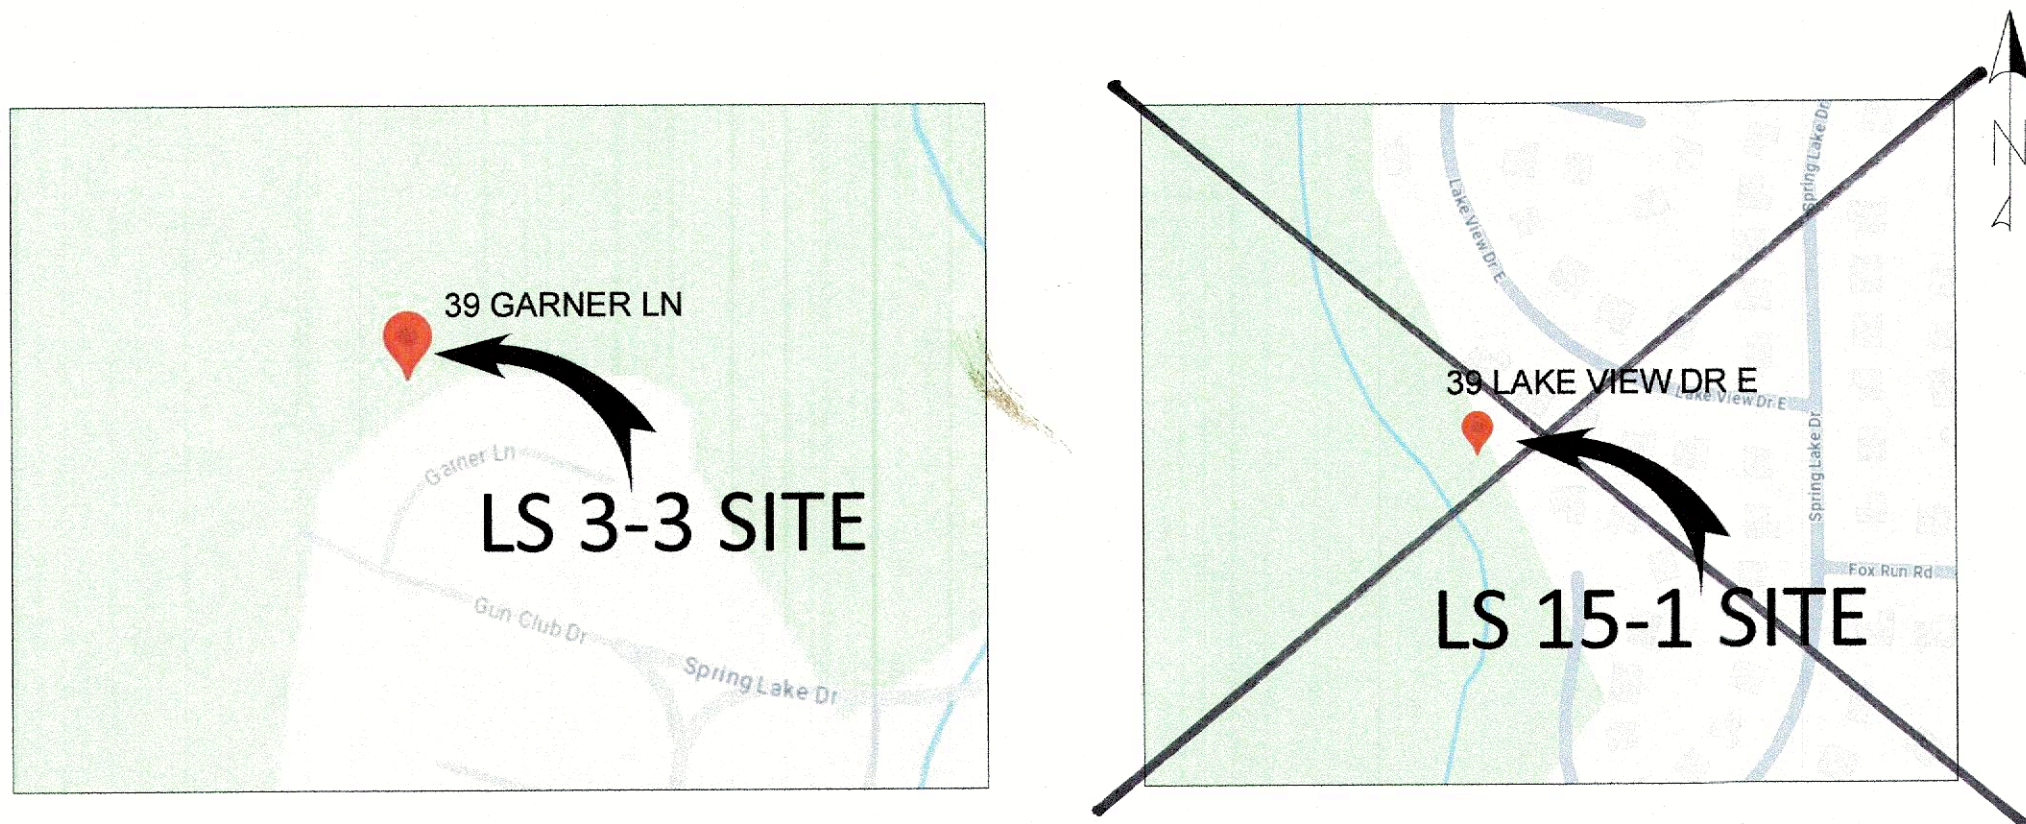

SCHEDULE OF DRAWINGS

G1	COVER SHEET
C1	LS 3-3 PLAN & PROFILE (EXISTING)
C2	LS 3-3 PLAN & PROFILE (PROPOSED)
C3	LS ASSEMBLY
C4	LS 15-1 PLAN & PROFILE (EXISTING)
C5	LS 15-1 PLAN & PROFILE (PROPOSED)
C6	LS ASSEMBLY
D1	DETAILS
E1	ELECTRICAL LEGEND AND ABBREVIATIONS
E2	ELECTRICAL SITE PLAN LS 3-3
E3	ELECTRICAL ONE LINE DIAGRAM LS 3-3
E4	ELECTRICAL SITE PLAN LS 15-1
E5	ELECTRICAL ONE LINE DIAGRAM LS 15-1
E6	ELECTRICAL DETAILS

LOCATION MAP

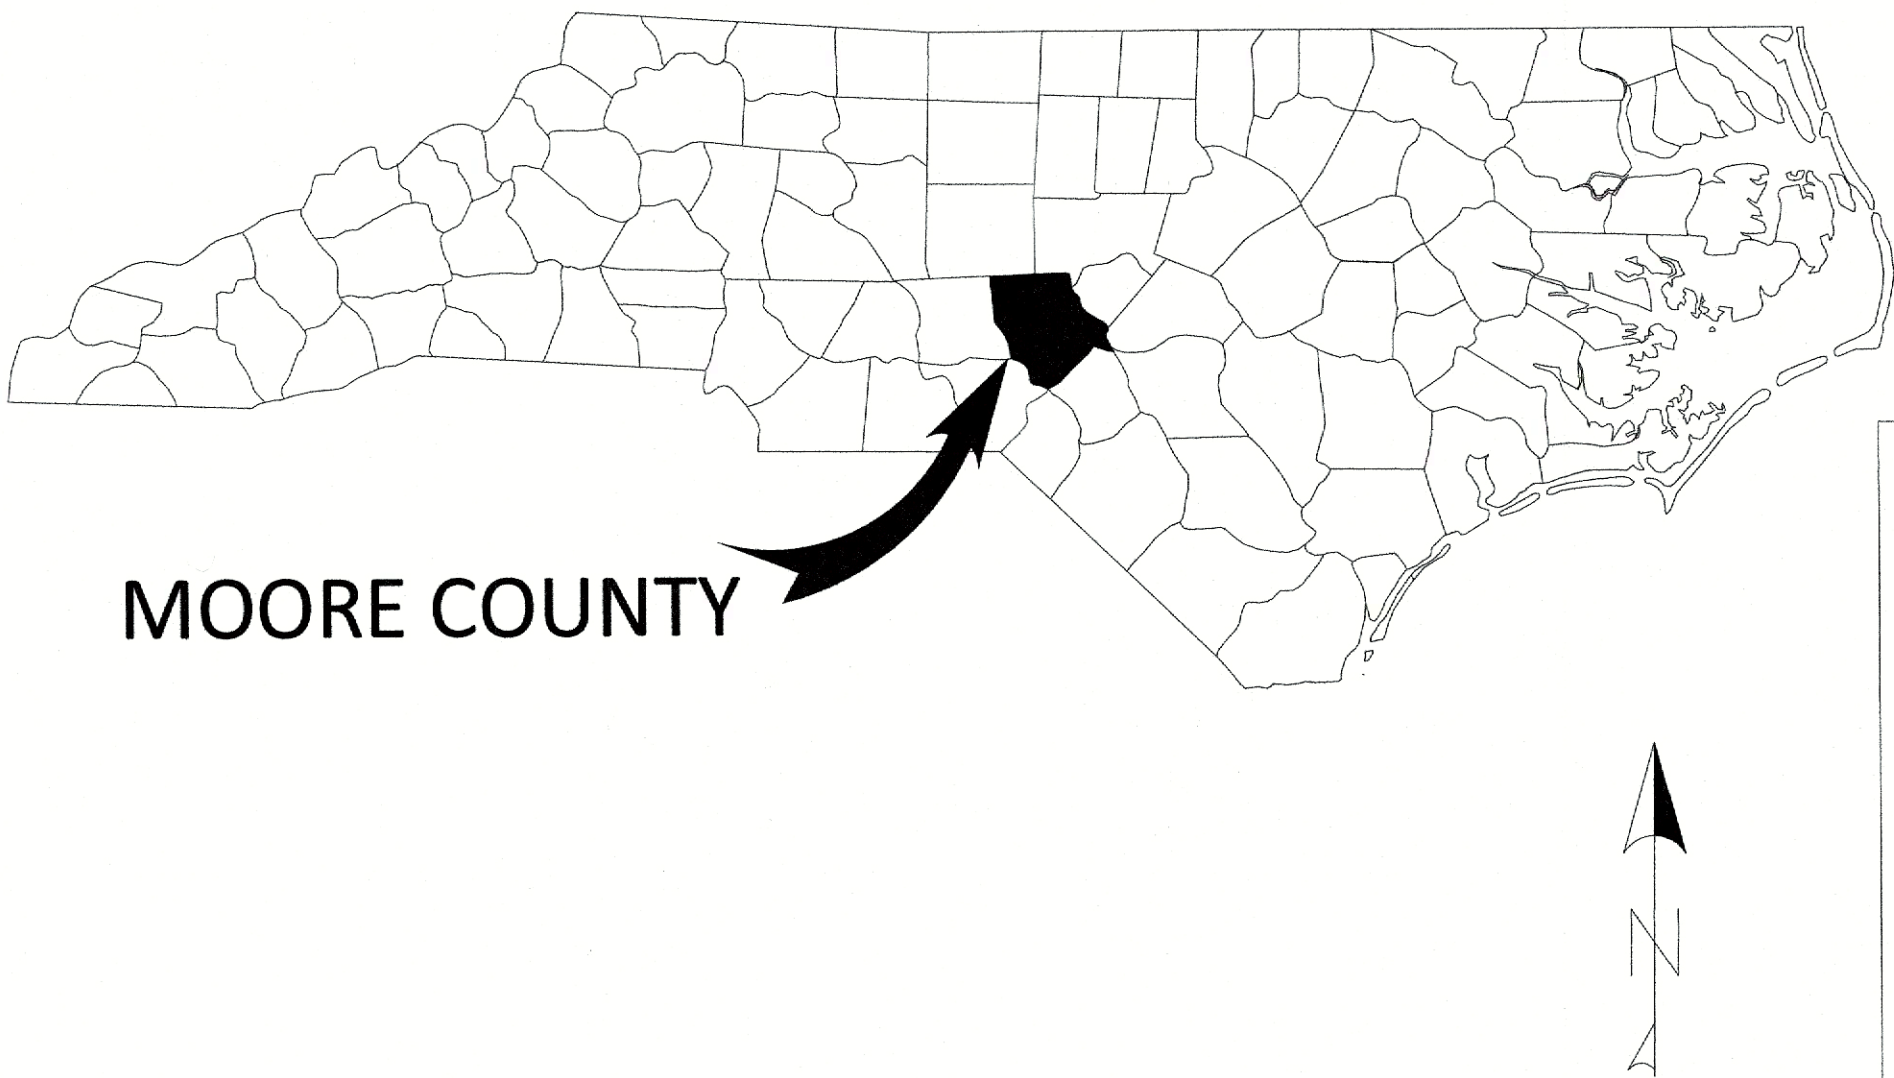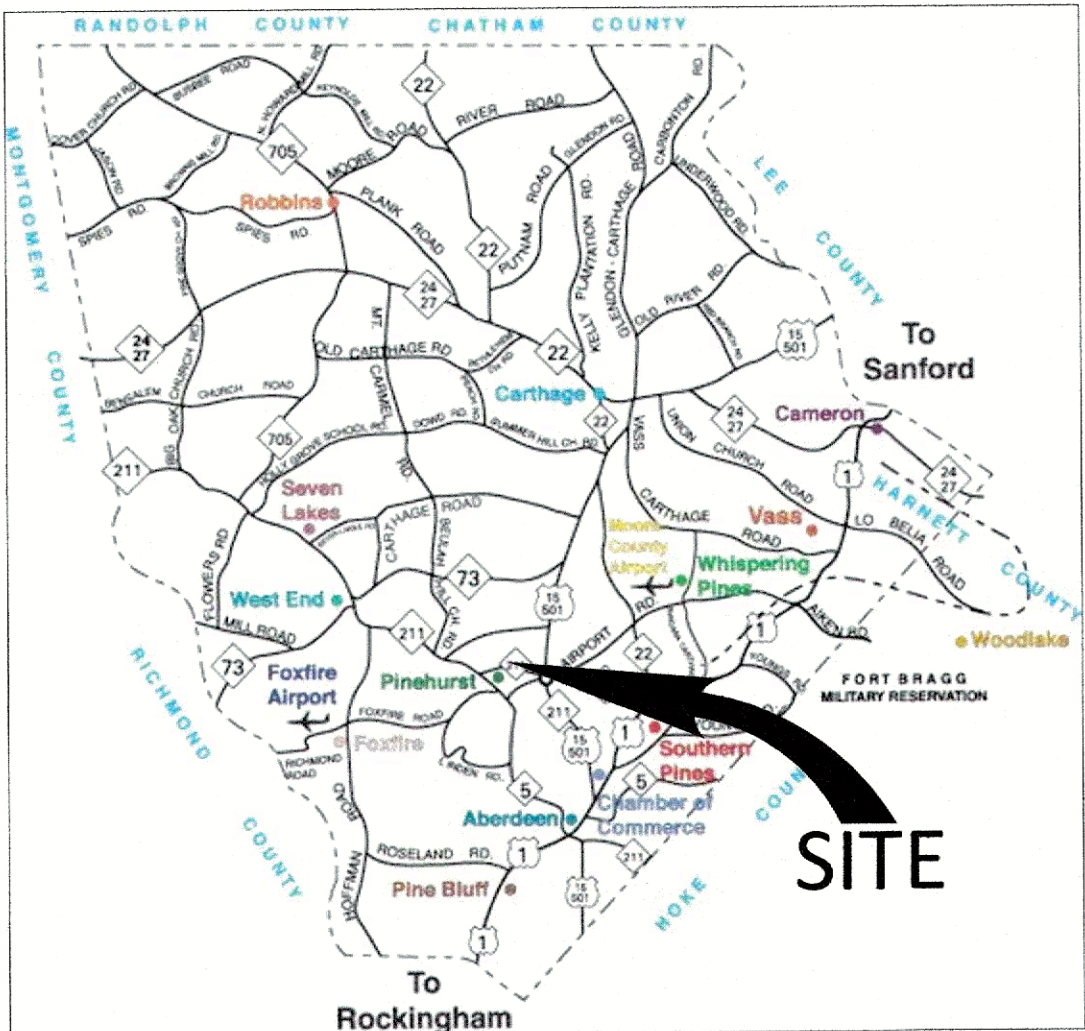

CALL BEFORE YOU DIG!
NC ONE CALL CENTER





811 or 1-800-632-4949
CALL THREE DAYS
BEFORE DIGGING

Approval Signatures




Building Inspection	_____	Date	_____
Fire Marshal	_____	Date	_____
Planning	_____	Date	_____
Public Works	_____	Date	_____
Environmental Health	_____	Date	_____

All Construction Methods and Materials shall be in accordance with Moore County and NCDOT Standards and Specifications. In the event of a conflict between standards, the more stringent shall govern unless a written waiver is issued by Moore County. Utility installations and other Public Facilities have been approved by Moore County and shall be so installed unless a change is authorized by prior written approval. Public Utility Easements shall be recorded prior to final acceptance, execution of the Deed of Dedication for Utilities and/or issuance of a Certificate of Occupancy by the County of Moore.

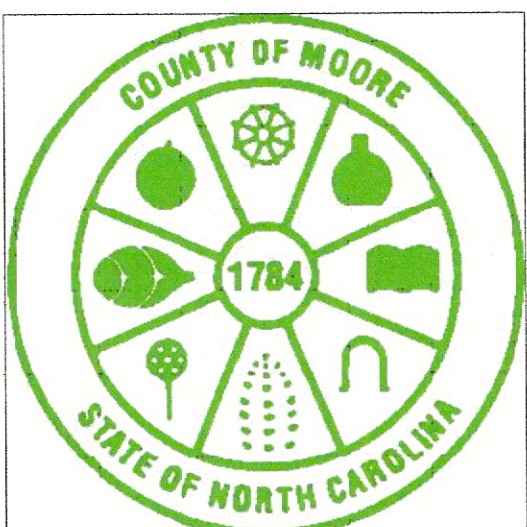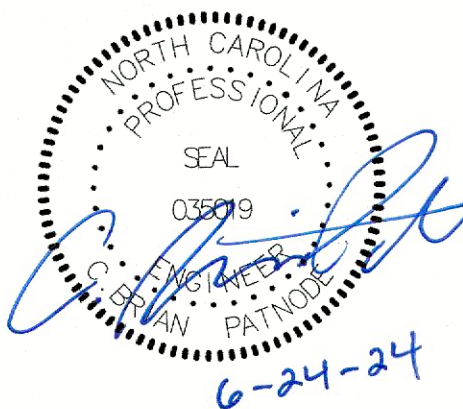


MOORE COUNTY PUBLIC WORKS

www.moorecountync.gov
5227 HWY 15-501
P.O. BOX 1927
CARTHAGE, NC 28327
(910) 947-6315

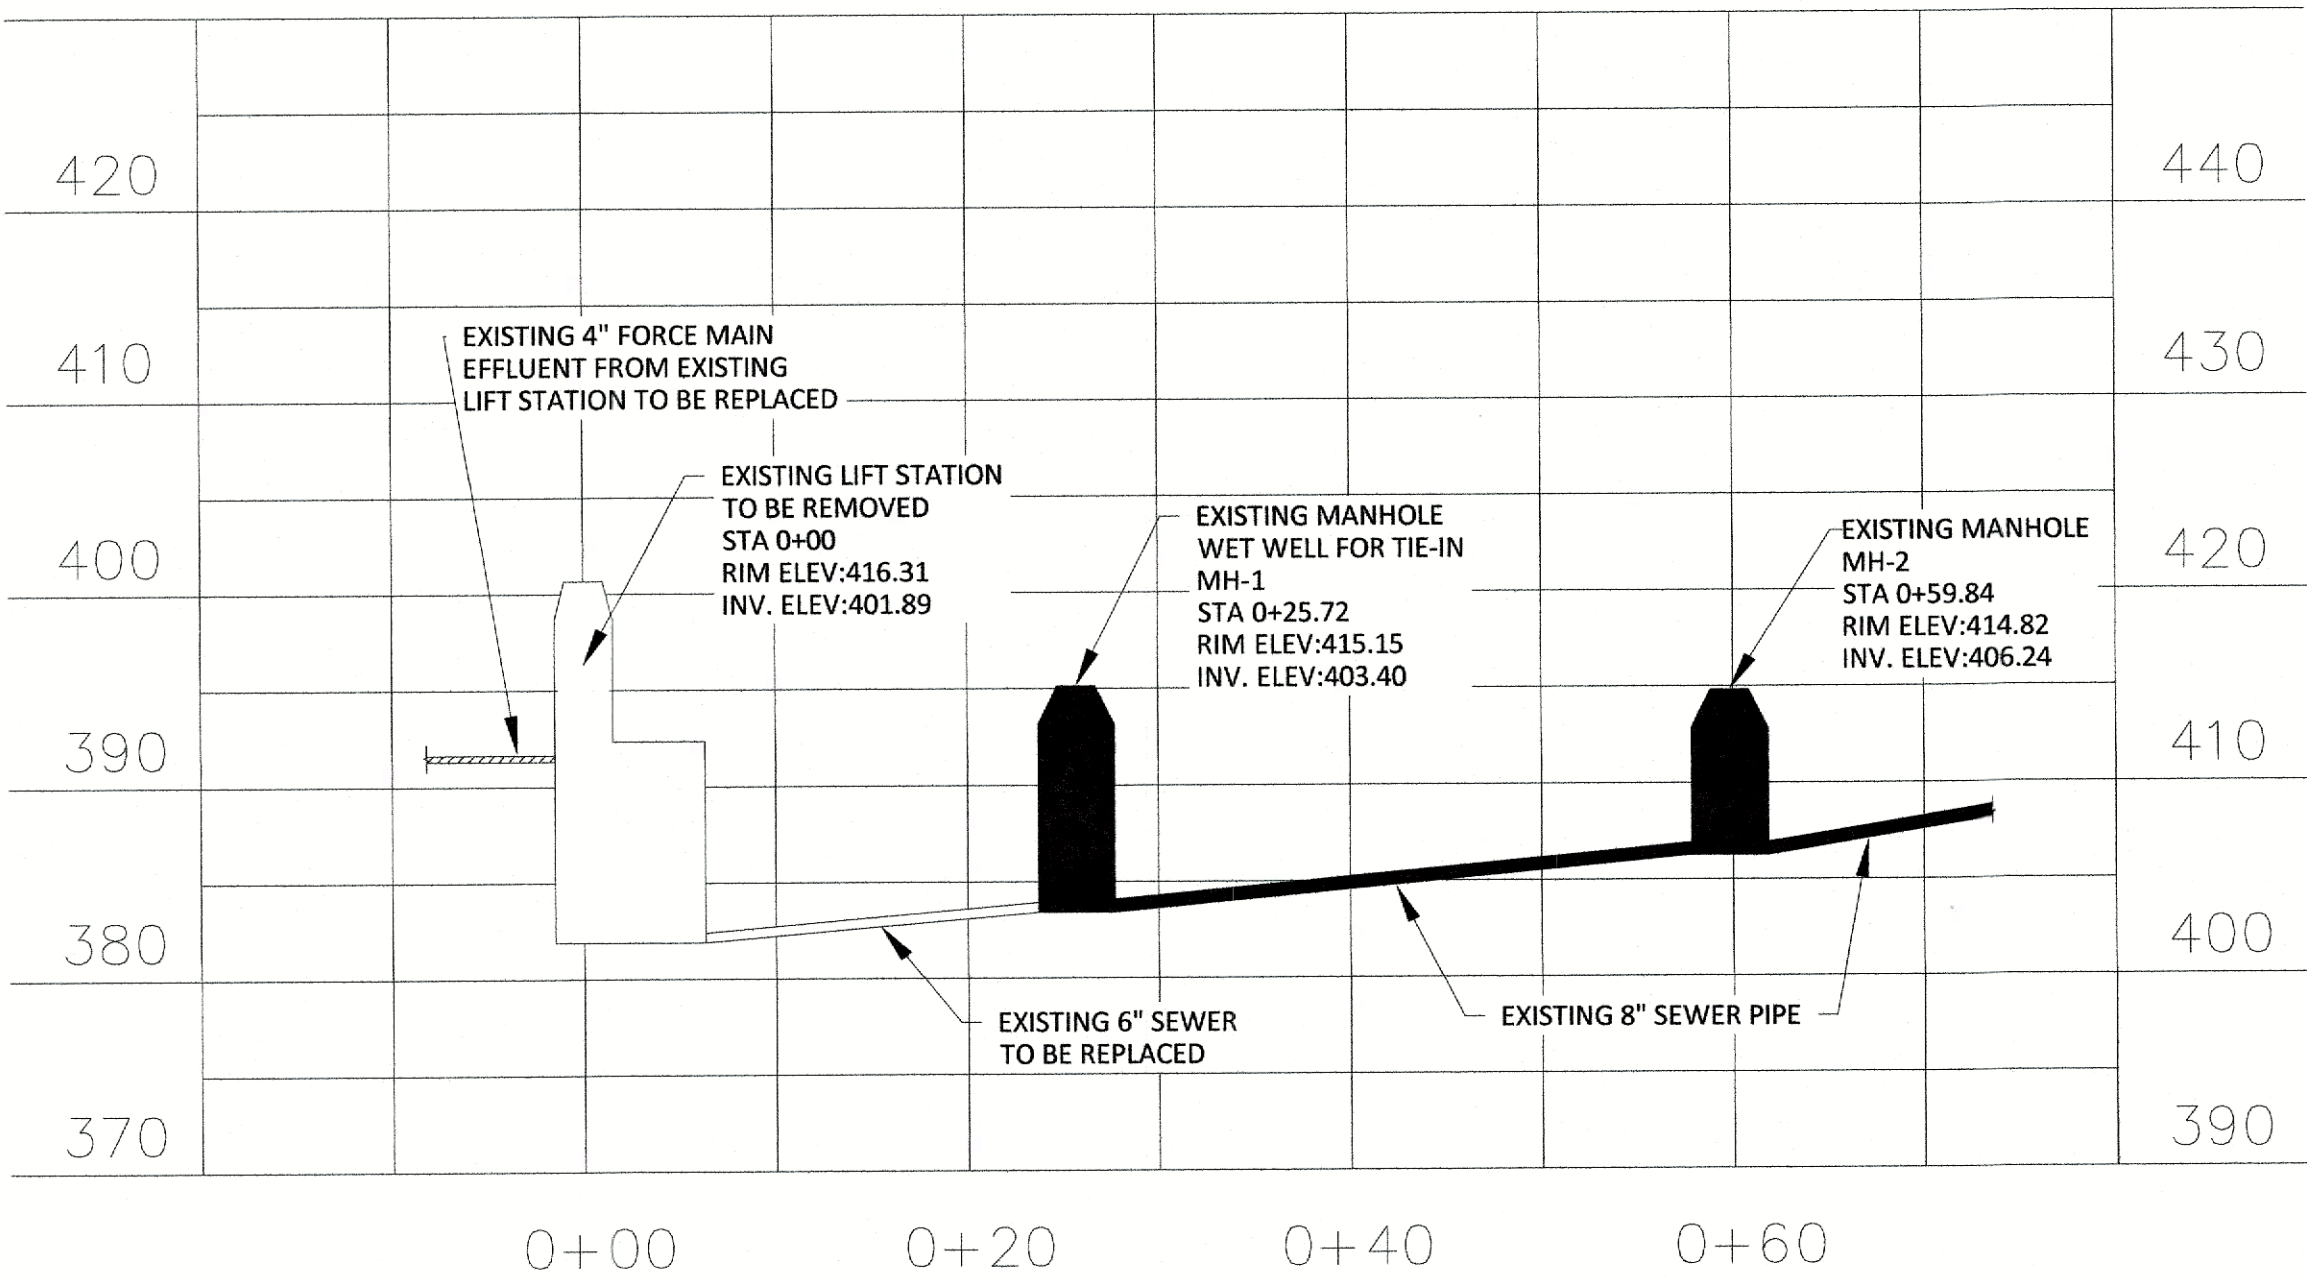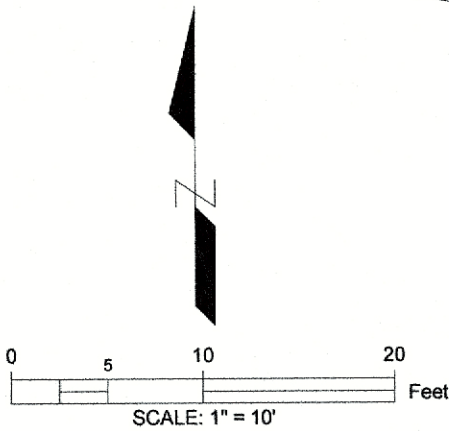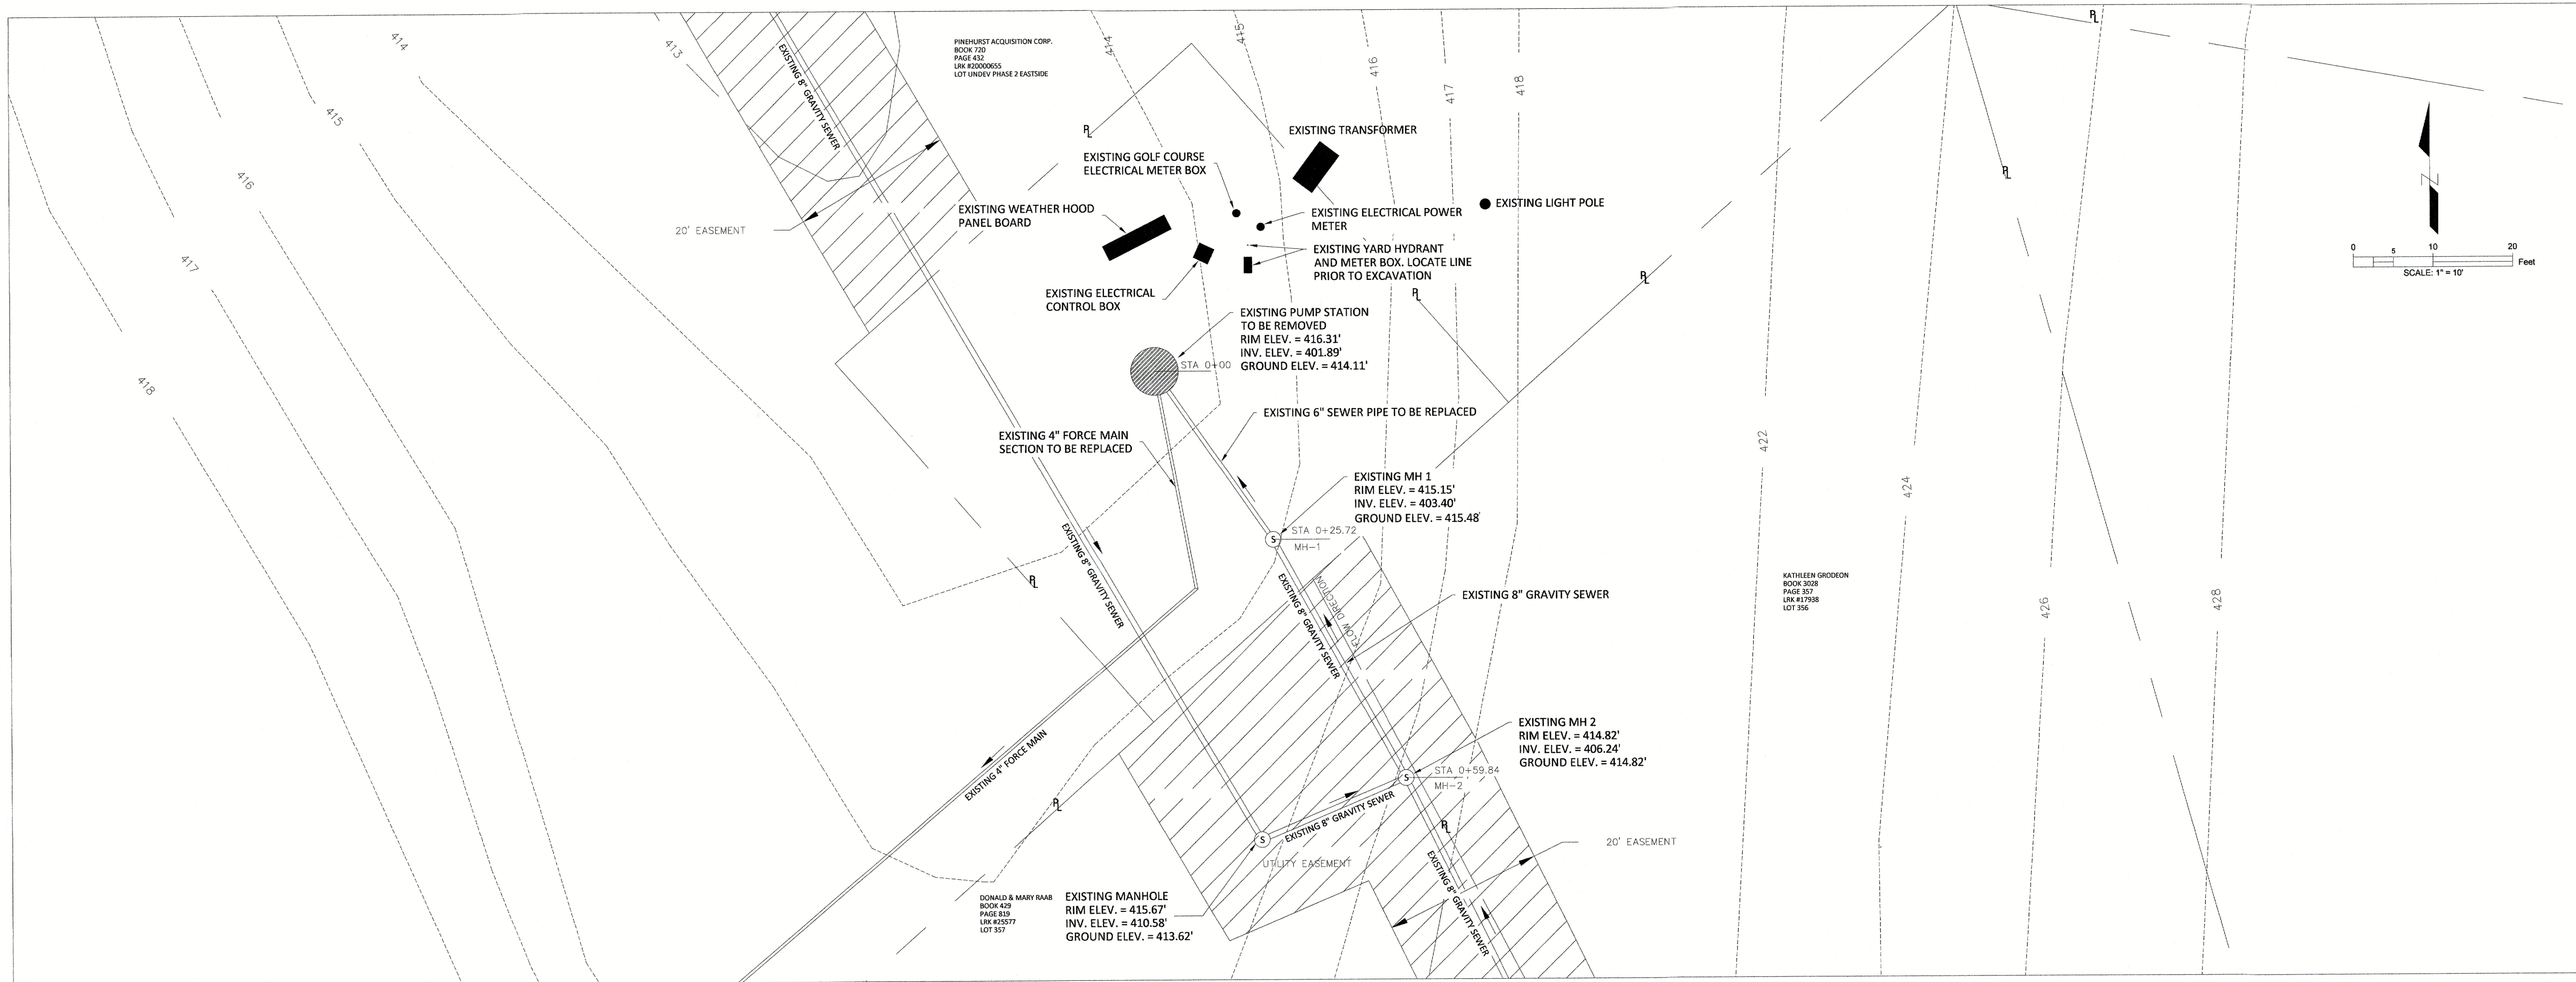

Existing Sewer Profile
Horizontal Scale: 1"=10'
Vertical Scale: 1"=10'

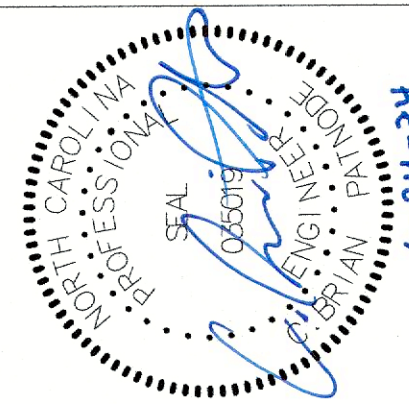

**LIFT STATIONS 3-3 & 15-1
REPLACEMENTS**

PINEHURST, NC

DATE: MAY 2024
DESIGNED BY: CBP
CADD BY: DFH

LS 3-3
PLAN AND PROFILE
EXISTING & DEMOLITION

REVISIONS		DESCRIPTION	
NO.	DATE	BY	DESCRIPTION

REVISED		MOORE COUNTY PUBLIC WORKS ENGINEERING DIVISION	RUBBER BOOT	STD NO. SS-15
DATE	DESCRIPTION			

FEBRUARY 2024

REVISED		MOORE COUNTY PUBLIC WORKS ENGINEERING DIVISION	SAFETY PLACARD	STD NO. PS-11
DATE	DESCRIPTION			

JUNE 2017

REVISED		MOORE COUNTY PUBLIC WORKS ENGINEERING DIVISION	SANITARY YARD HYDRANT	STD NO. PS-2
DATE	DESCRIPTION			

JUNE 2017

REVISED		MOORE COUNTY PUBLIC WORKS ENGINEERING DIVISION	PIPE INSTALLATION PVC & DIP	STD NO. SS-2
DATE	DESCRIPTION			

FEBRUARY 2024


REVISED		MOORE COUNTY PUBLIC WORKS ENGINEERING DIVISION	IDENTIFICATION SIGN	STD NO. PS-14
DATE	DESCRIPTION			

JUNE 2017

NOTES:
1. ALL MATERIALS AND INSTALLATION SHALL BE IN ACCORDANCE WITH MCPU STANDARDS.
2. ALL BELOW GRADE FITTINGS SHALL BE MECHANICAL JOINT.
3. ALL PIPE SHALL BE RESTRAINED JOINT D.I.P. CLASS 350
4. ALL PIPE AND FITTINGS TO BE LINED WITH PROTECTO 401 OR AN APPROVED EQUAL.

REVISED		MOORE COUNTY PUBLIC WORKS ENGINEERING DIVISION	EMERGENCY PUMP CONNECTION	STD NO. PS-1
DATE	DESCRIPTION			

JUNE 2017

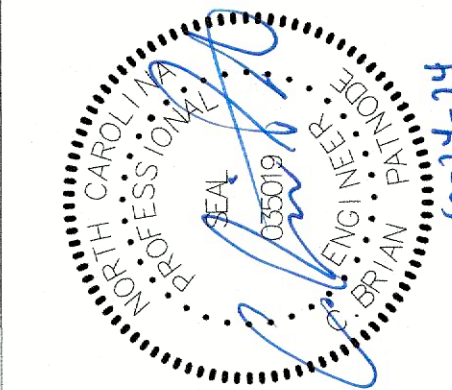


LIFT STATIONS 3-3 & 15-1
REPLACEMENTS


PINEHURST, NC

DATE: MAY 2024 DESIGNED BY: CBP CADD BY: DFH	
DETAILS	
REVISIONS	
NO.	DATE BY DESCRIPTION

ONE - LINES

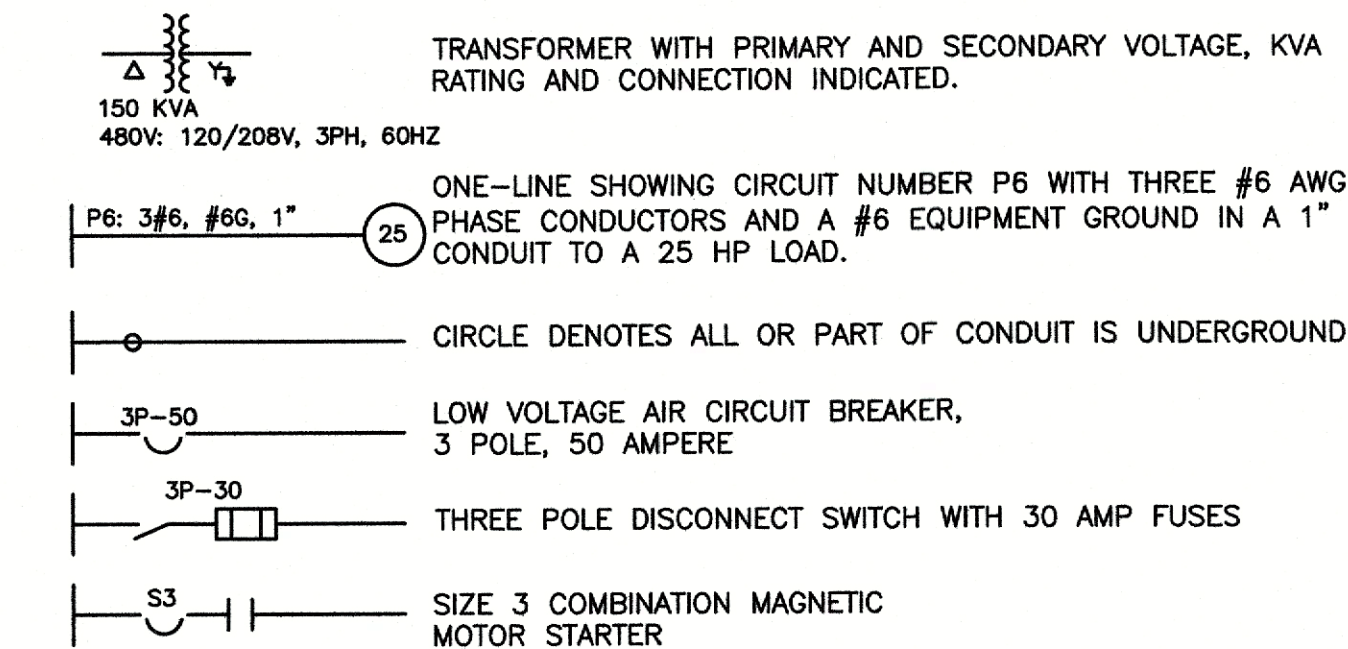

PLANS

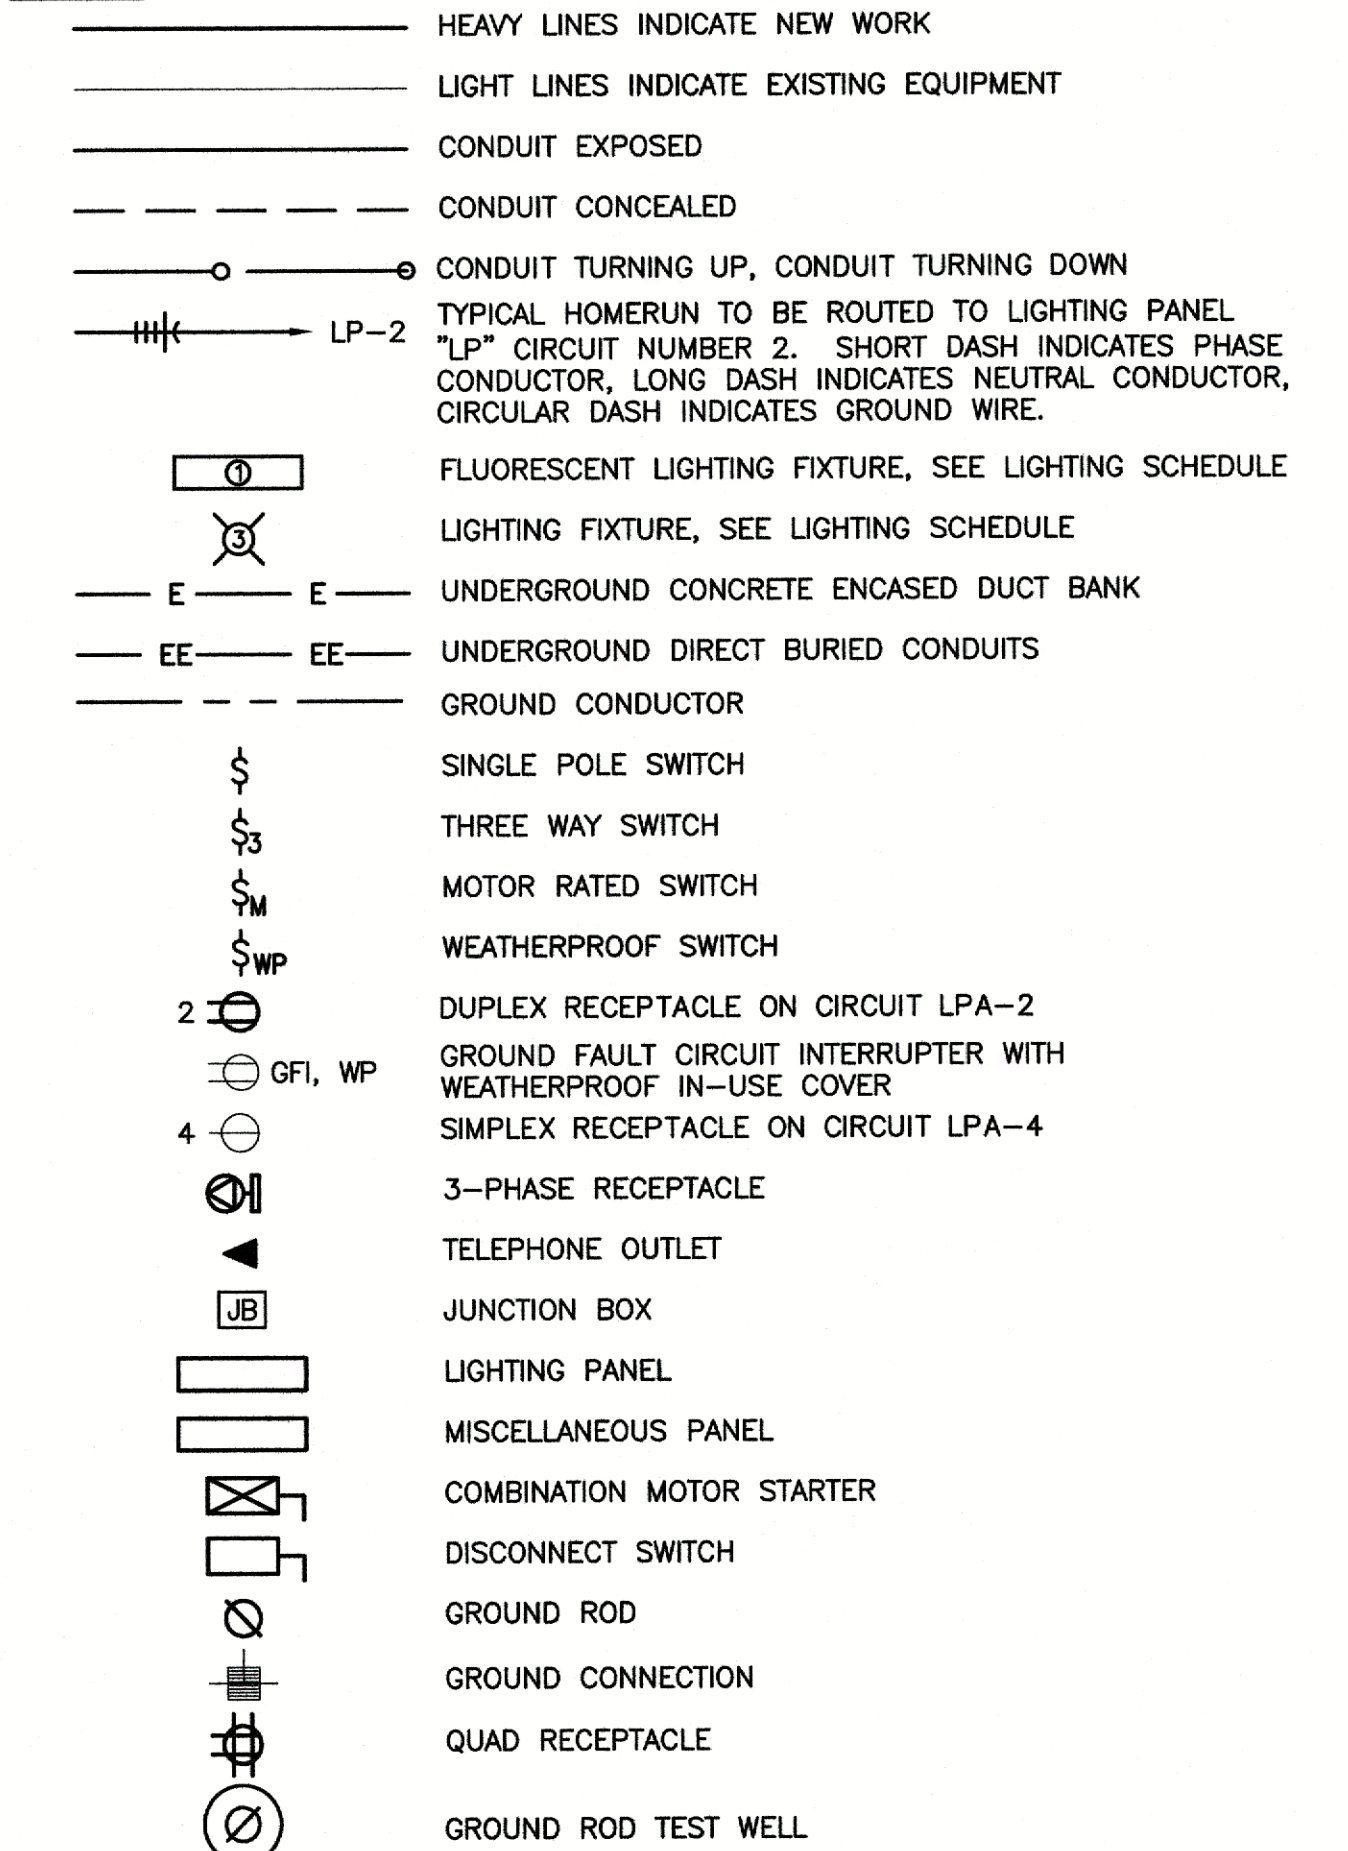


ELECTRICAL LEGEND AND SYMBOLS

SCALE: NOT TO SCALE


GENERAL NOTES:

- CONTRACTOR SHALL PROVIDE ALL LABOR, MATERIALS, TOOLS, EQUIPMENT, PERMITS, AND OPERATIONS NECESSARY FOR THE PROPER EXECUTION AND COMPLETION OF ALL ELECTRICAL WORK INDICATED ON THE DRAWINGS.
- ALL ELECTRICAL WORK AND MATERIALS SHALL COMPLY WITH THE NEC AND OTHER APPLICABLE FEDERAL, STATE (VOSH), AND LOCAL CODES, ALL ELECTRICAL EQUIPMENT SHALL BE UL OR SUITABLE THIRD PARTY LISTED OR LABELED.
- ALL DISCONNECT SWITCHES, JUNCTION BOXES, MOTOR CONTROLLERS, AND OTHER EQUIPMENT REQUIRING ELECTRICAL POWER CONNECTION SHALL BE MARKED WITH VOLTAGE PRESENT, AS APPROPRIATE TO DESIGNATE 120, 208, 240, 277, 480 VOLTS AND SINGLE OR THREE PHASE, AS APPLICABLE.
- CONTRACTOR SHALL BE RESPONSIBLE FOR ROUTING ALL CONDUITS. THIS INCLUDES CONDUITS ON ONE-LINES AND HOMERUNS ON PLANS. CABLE AND CONDUIT MAY NOT ALWAYS BE SHOWN ON ALL PLAN SHEETS. UNDERGROUND DUCT BANKS SHALL BE ROUTED TO AVOID INTERFERENCE WITH EXISTING EQUIPMENT.
- CONTRACTOR SHALL VERIFY ALL EQUIPMENT LOCATIONS AND CONNECTION POINTS PRIOR TO INSTALLATION.
- UNLESS OTHERWISE NOTED, MOUNT LIGHT SWITCHES AND CONVENIENCE RECEPTACLES 45" ABOVE FINISHED FLOOR. ALL CONVENIENCE RECEPTACLES SHALL HAVE GROUND FAULT PROTECTION.
- (—————) SOLID LINES INDICATE NEW WORK OR EQUIPMENT.
- (————) SCREENED OR LIGHT WEIGHT LINES INDICATE EXISTING WORK OR EQUIPMENT.
- (- - - -) DASHED LINES INDICATE FUTURE WORK OR EQUIPMENT.
- THIS IS A GENERAL LEGEND SHEET. SOME SYMBOLS AND ABBREVIATIONS MAY NOT BE UTILIZED ON THIS SPECIFIC PROJECT.
- HATCHED AREAS  ON ONE-LINES AND ELEVATIONS INDICATE EQUIPMENT TO BE REMOVED BY THE CONTRACTOR.

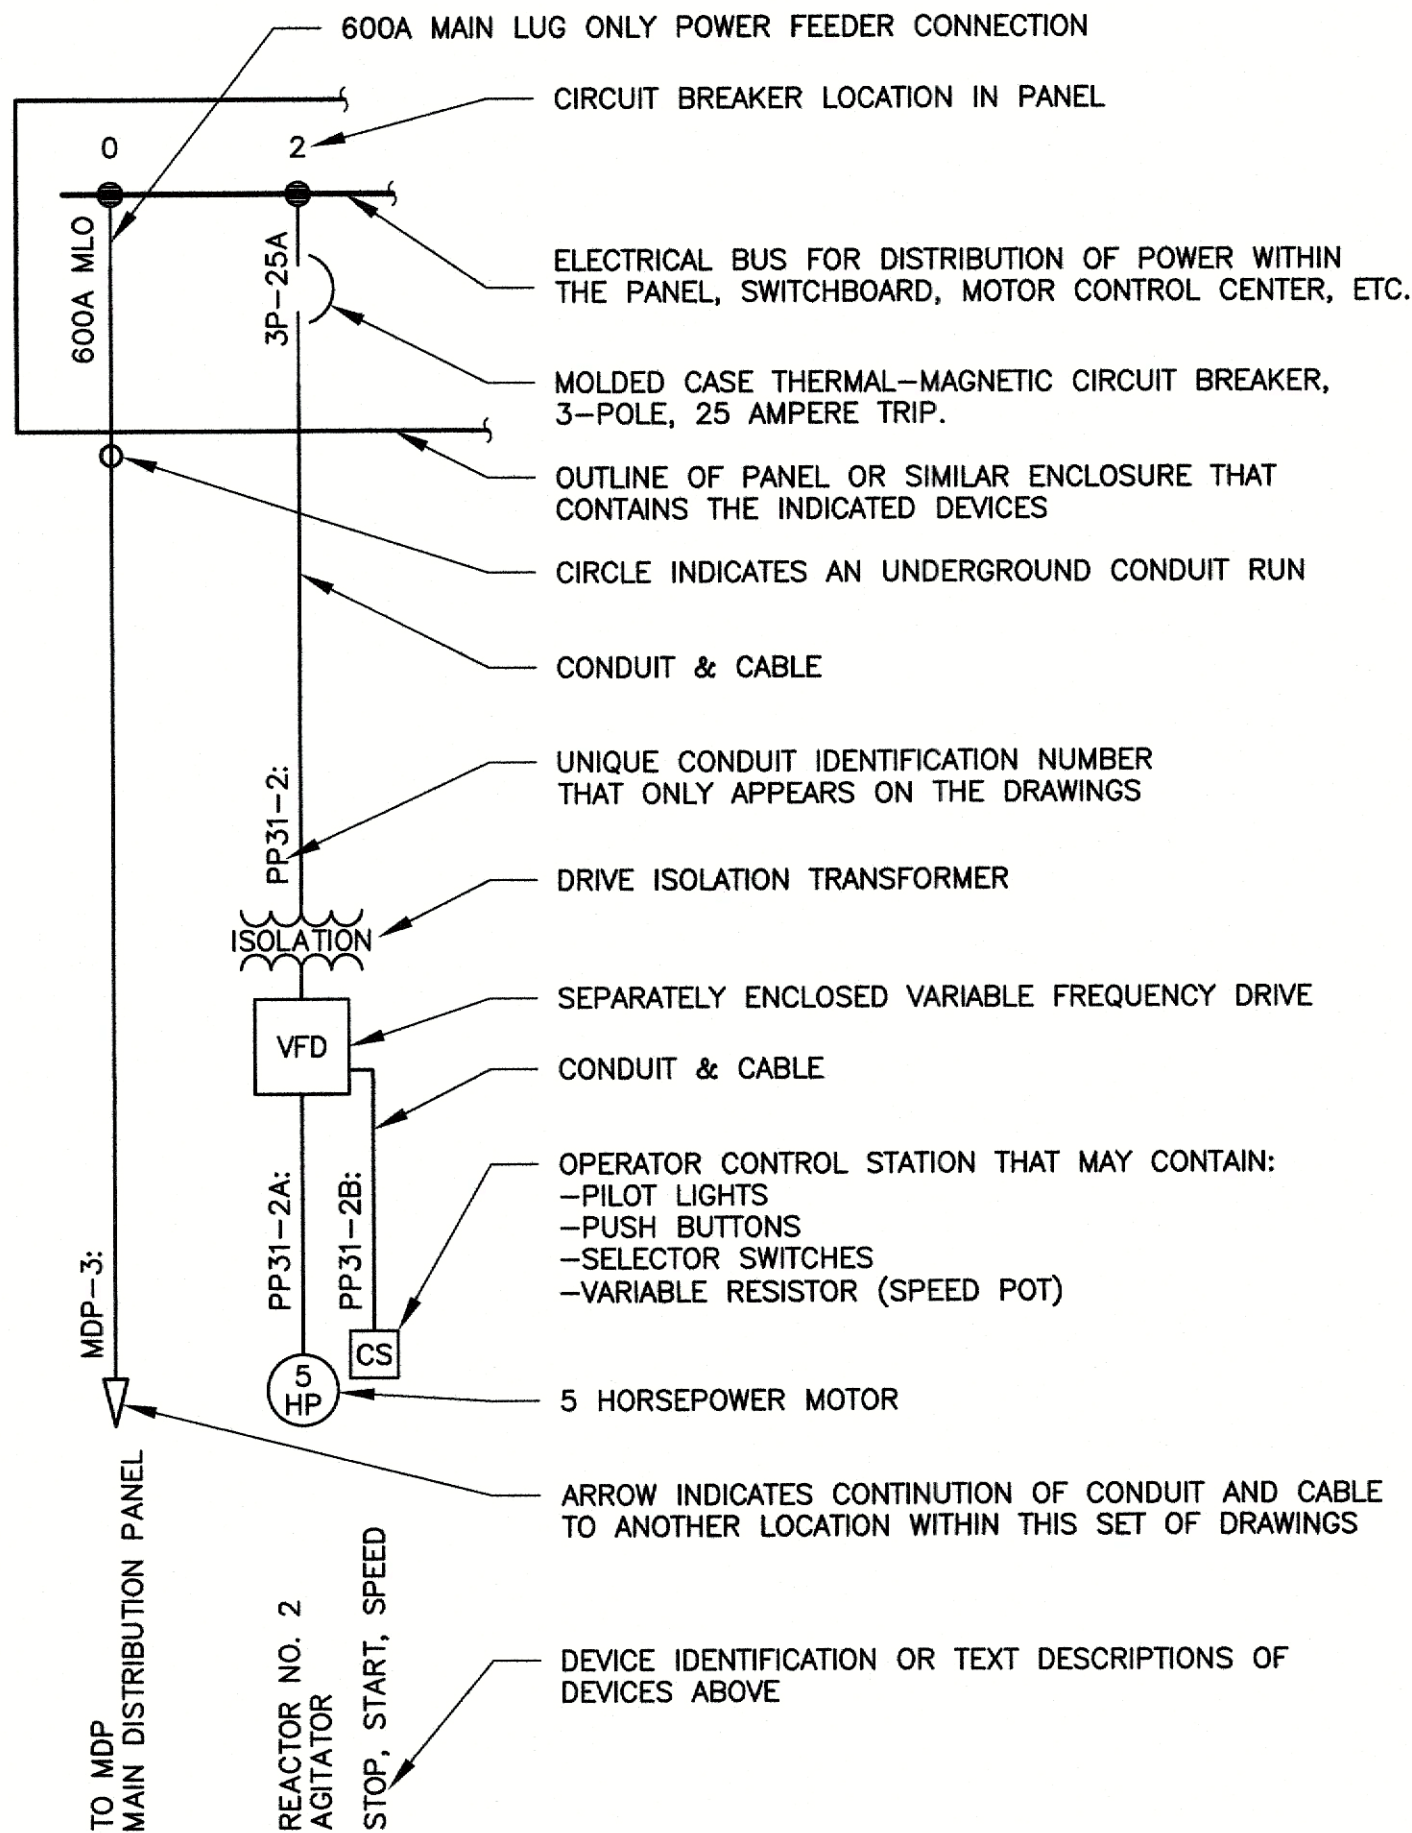

ELECTRICAL ONE-LINE DIAGRAM LEGEND

SCALE: NOT TO SCALE

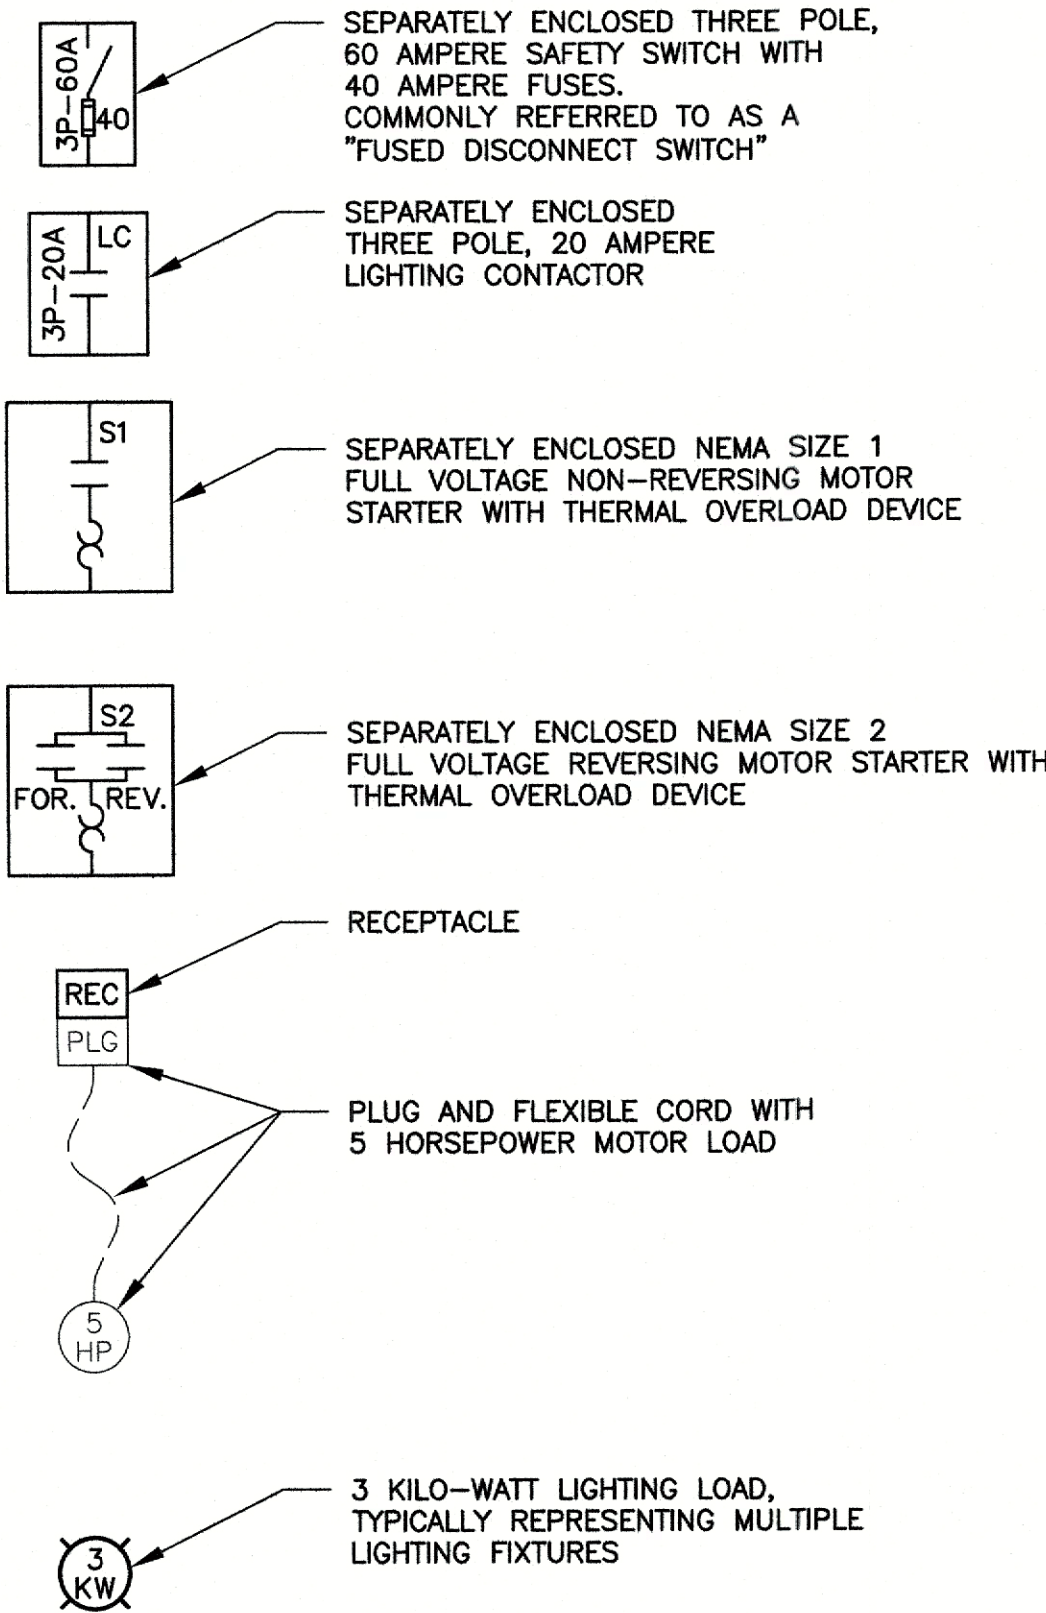

A	AMPERE	MCC	MOTOR CONTROL CENTER
AC	ALTERNATING CURRENT	MCP	MOTOR CIRCUIT PROTECTOR
A/C	AIR CONDITIONER	MDP	MAIN DISTRIBUTION PANEL
AFF	ABOVE FINISHED FLOOR	MIN	MINIMUM
AGL	ABOVE GROUND LEVEL	MLO	MAIN LUG ONLY
AMP	AMPERE	MPC	MINI-POWER CENTER
ATS	AUTOMATIC TRANSFER SWITCH	MPZ	MINI-POWER ZONE
AWG	AMERICAN WIRE GAUGE	MTS	MANUAL TRANSFER SWITCH
BPS	BOOSTER PUMP STATION	MSH	MOTOR SPACE HEATER
C	CONDUIT	MS	MOTOR STARTER
CB	CIRCUIT BREAKER	N	NEUTRAL
CFL	COMPACT FLOURESCENT	NEC	NATIONAL ELECTRICAL CODE
CP	CONTROL PANEL	NEMA	NATIONAL ELECTRICAL MANUF. ASSOC.
CR	CONTROL RELAY	OL	OVERLOAD (RELAY)
CS	CONTROL STATION	PB	PUSH BUTTON
CT	CURRENT TRANSFORMER	PCP	PUMP CONTROL PANEL
DC	DIRECT CURRENT	PE	PHOTO-ELECTRIC CONTROL
DIA	DIAMETER	PH	PHASE
DM	DAMPER MOTOR	PL	PILOT LIGHT
DS	DISCONNECT SWITCH	PLC	PROGRAMMABLE LOGIC CONTROLLER
DSG	GENERATOR DISCONNECT SWITCH	PMR	POWER MONITOR RELAY
DSU	UTILITY DISCONNECT SWITCH	PP	POWER PANEL
EB	ELECTRONIC BALLAST	PROP.	PROPOSED
EC	EMPTY CONDUIT	PSCP	PUMP STATION CONTROL PANEL
E.C.	ELECTRICAL CONTRACTOR	R	RED
EF	EXHAUST FAN	REQD	REQUIRED
EL	ELEVATION	RTU	REMOTE TELEMETRY UNIT
EHH	ELECTRICAL HAND HOLE	RVAT	REDUCED VOLTAGE
EWH	ELECTRIC WATER HEATER	SA	AUTOTRANSFORMER
EX.	EXISTING	SE	SURGE ARRESTOR
EXP	EXPLOSION PROOF	SP	SERVICE ENTRANCE
FE	FLOW ELEMENT	SS	SUB-PANEL
FWE	FURNISHED WITH EQUIPMENT	SSRV	SELECTOR SWITCH
G	GROUND		SOLID STATE REDUCED VOLTAGE
GEN	GENERATOR	SST	STAINLESS STEEL
GFCI	GROUND FAULT CIRCUIT INTERRUPTER	SSW	SELECTOR SWITCH
GFI	GROUND FAULT INTERRUPTER	T	THERMOSTAT
GND	GROUND	TS	TEMPERATURE SWITCH
HID	HIGH INTENSITY DISCHARGE (LIGHT)	TVSS	TRANSIENT VOLTAGE SURGE SUPPRESSOR
HOA	HAND-OFF-AUTOMATIC	TYP	TYPICAL
HP	HORSEPOWER	UH	UNIT HEATER
HVAC	HEATING, VENTILATION, & AIR COND.	UM	UTILITY METER
HZ	HERTZ	V	VOLTS
JB	JUNCTION BOX	VAC	VOLTS ALTERNATING CURRENT
KVA	KILOVOLT-AMPERE	VFD	VARIABLE FREQUENCY DRIVE
KW	KILOWATT	W	WATTS OR WHITE
LAHJ	LOCAL AUTHORITY HAVING JURISDICTION	WP	WEATHERPROOF
LE	LEVEL ELEMENT	XP	EXPLOSION PROOF
LP	LIGHTING PANEL	ZS	POSITION SWITCH
LS	LEVEL SWITCH	3-PH	THREE PHASE
LSH	LEVEL SWITCH - HIGH	4P	FOUR POLE
LSL	LEVEL SWITCH - LOW	&	AND
M	MAGNETIC MOTOR STARTER		
M	MOTOR		
MA	MILLIAMPERE		
MAX	MAXIMUM		
MCB	MAIN CIRCUIT BREAKER		

- 2(3#350), #1N, 4" TWO PARALLEL SETS OF 3-PHASE 350MCM CONDUCTORS, ONE #1AWG NEUTRAL CONDUCTOR, NO GROUNDING CONDUCTOR, IN ONE 4" CONDUIT.
- 3(1PR#18STP) THREE - SINGLE PAIR, #18 AWG SHIELDED TWISTED PAIR CABLES
- 2(1TR#18STT) TWO - SINGLE TRIADS, #18 AWG SHIELDED TWISTED TRIAD CABLES
- 3#16STP THREE - #16 AWG SHIELDED TWISTED PAIR CABLES
- 3-7/C#14 THREE - SEVEN CONDUCTOR #14 AWG MULTICONDUCTOR CONTROL CABLES
- 2-RS485 TWO CABLES FOR RS485 COMMUNICATION

ELECTRICAL ABBREVIATIONS


SCALE: NOT TO SCALE

THE SCALE BAR SHOWN BELOW MEASURES ONE INCH LONG ON THE ORIGINAL DRAWING.



MOORE COUNTY PUBLIC WORKS

www.moorecountync.gov
5227 HWY 15-501
P.O. BOX 1927
CARTHAGE, NC 28327
(910) 947-6315

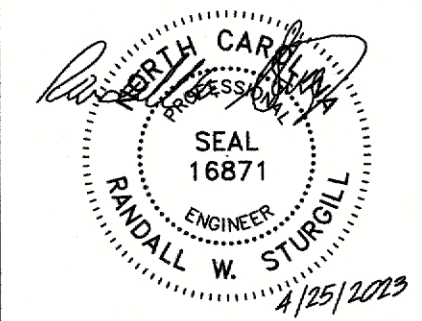

LIFT STATIONS 3-3 & 15-1
REPLACEMENT
PINEHURST, NC

DATE: APRIL 2023
DESIGNED BY: RWS
CADD BY: RWS

ELECTRICAL
LEGEND AND
ABBREVIATIONS

REVISIONS
DESCRIPTION
BY
DATE


SHEET

E1

THE SCALE BAR SHOWN BELOW
MEASURES ONE INCH LONG ON
THE ORIGINAL DRAWING.

STURGILL
ENGINEERING
PA. ONE SOUTH MAIN ST.
LEXINGTON, NC 27292
(336) 236-1249 PH.
(336) 236-6393 FAX

MOORE COUNTY PUBLIC WORKS
www.moorecountync.gov
5227 HWY 15-501
P.O. BOX 1927
CARTHAGE, NC 28327
(910) 947-6315

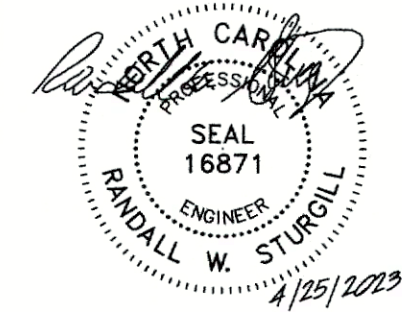


LIFT STATIONS 3-3 & 15-1
REPLACEMENT
PINEHURST, NC

DATE: APRIL 2023
DESIGNED BY: RWS
CADD BY: RWS

ELECTRICAL
SITE PLAN
LIFT STATION 3-3


NO.	DATE	BY	REVISIONS	
			DESCRIPTION	

SHEET
E2

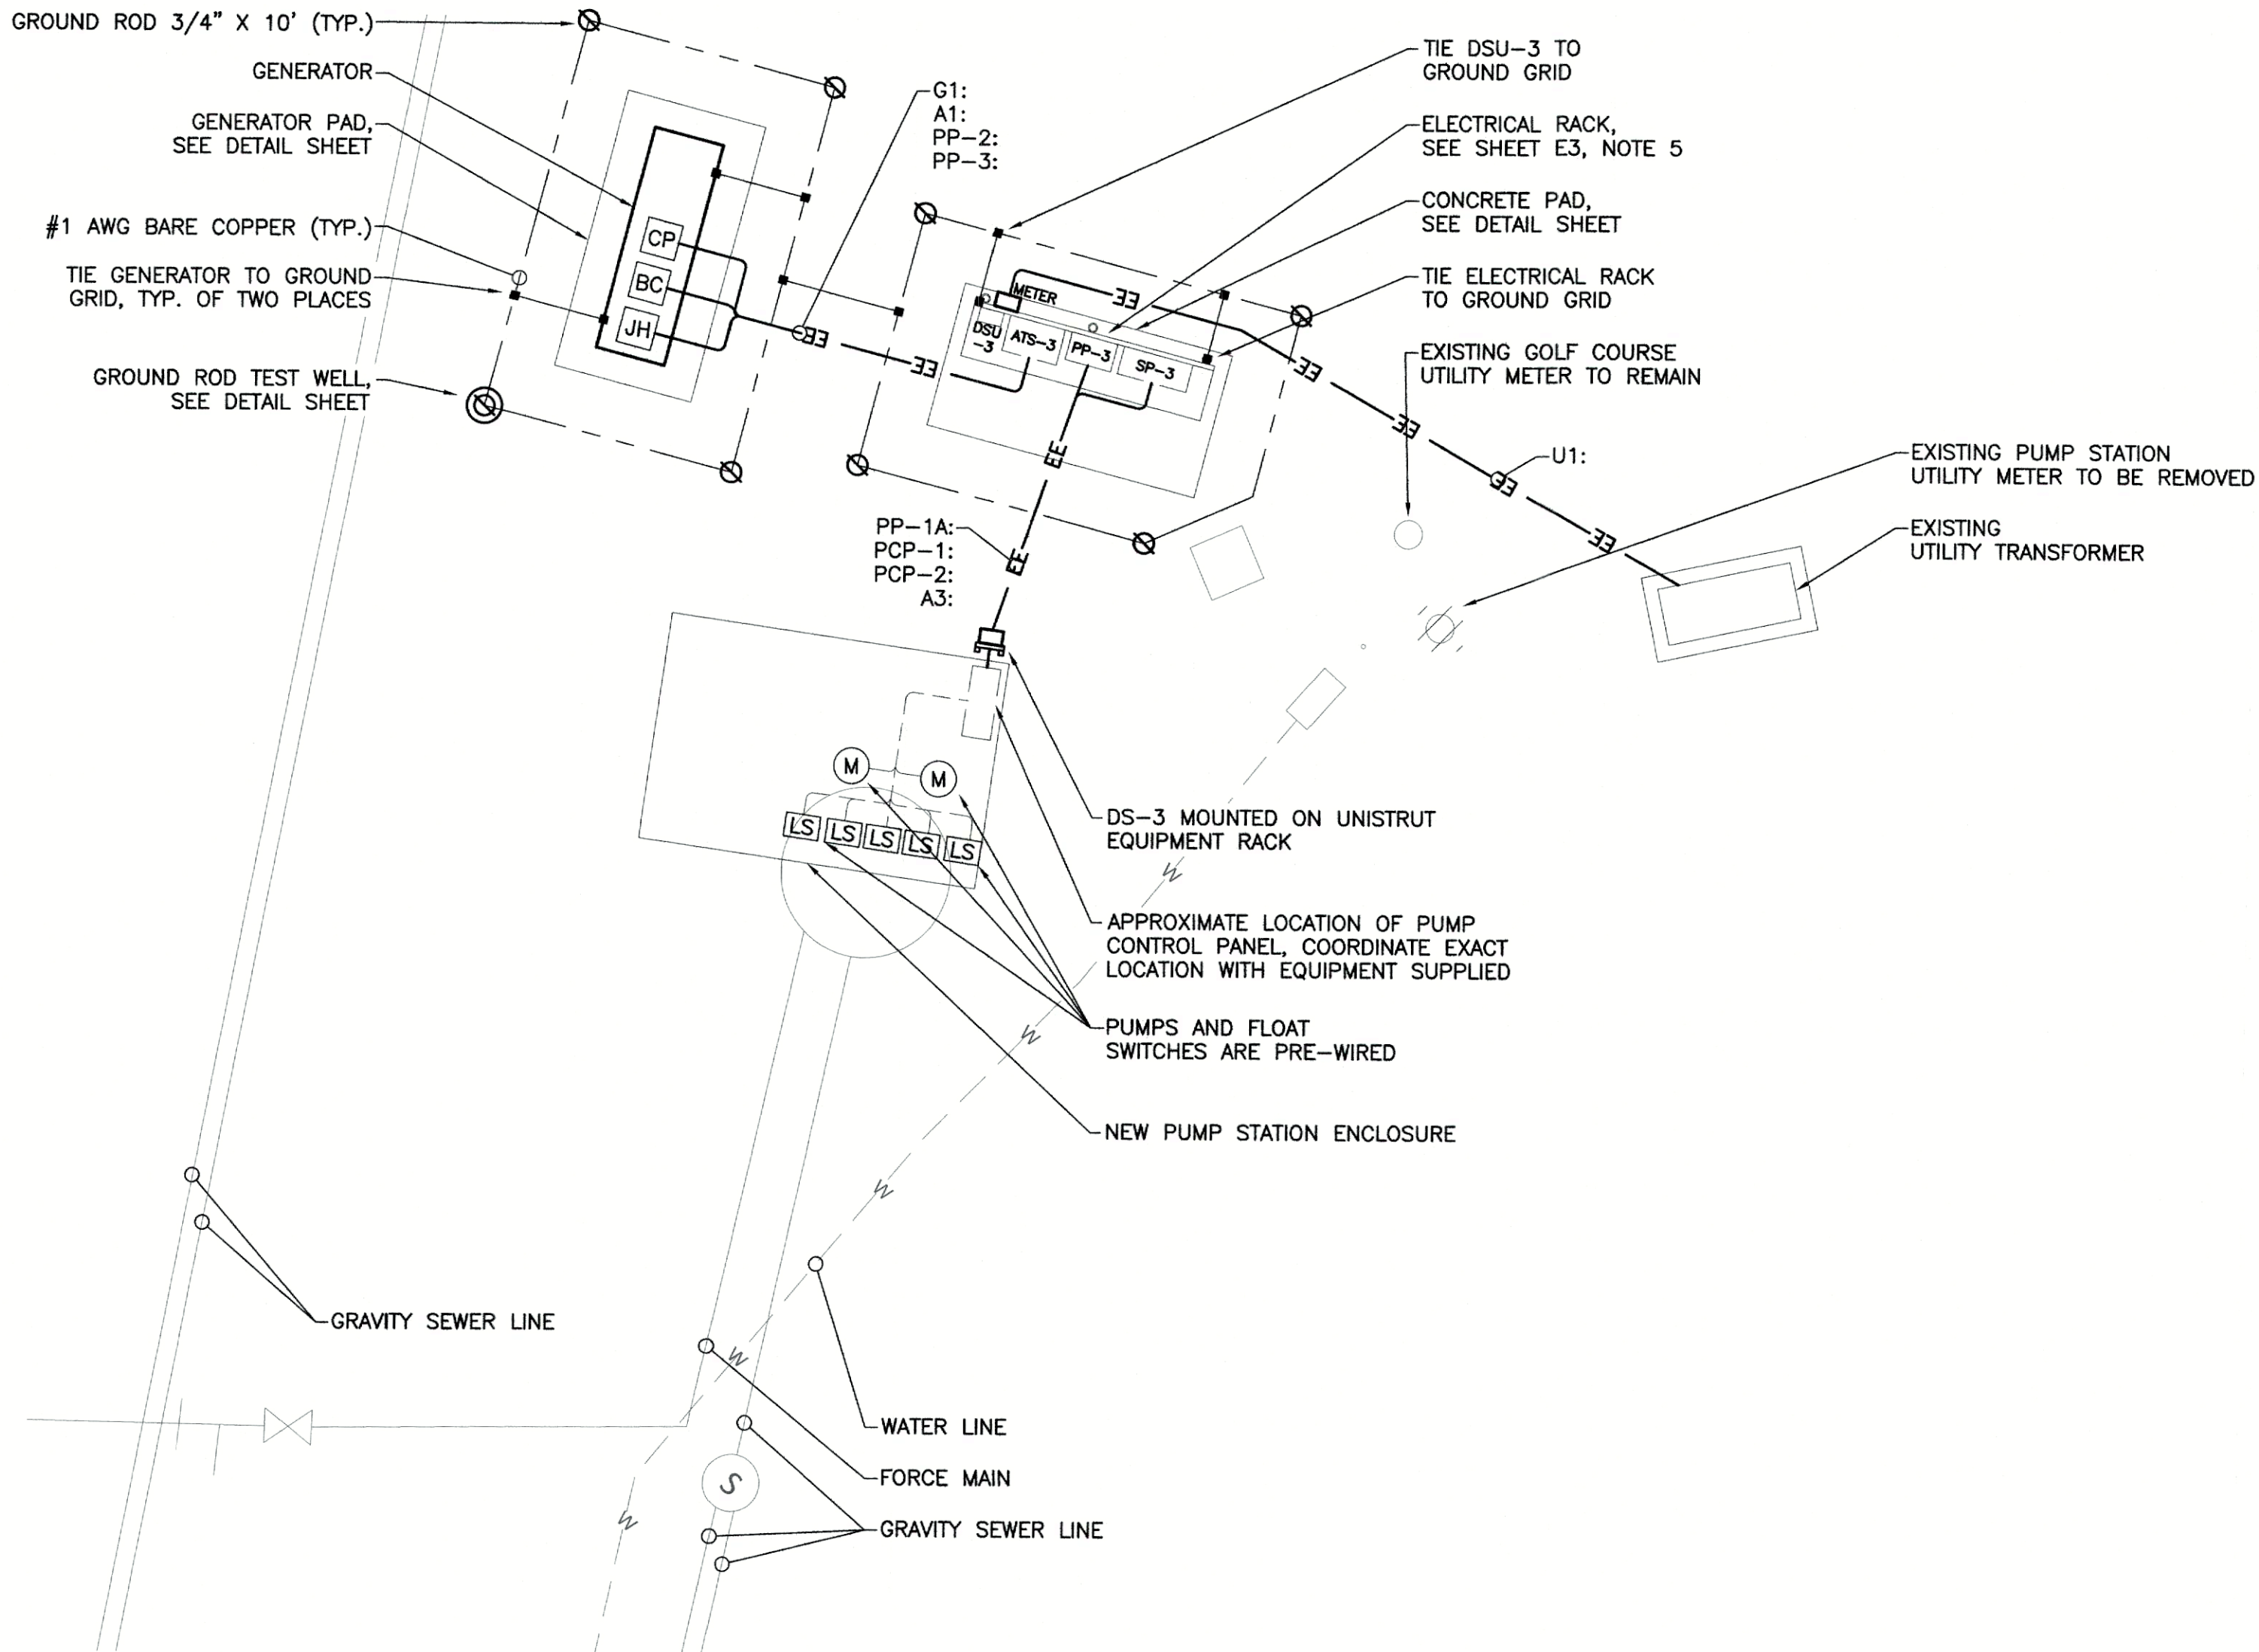

LIFT STATION 3-3 ELECTRICAL SITE PLAN
SCALE: 1" = 5' - 0"

- NOTES:
- SEE SHEET E0.01 FOR ELECTRICAL LEGEND, ABBREVIATIONS, AND NOTES.
 - INSTALL ALL ELECTRICAL EQUIPMENT AT LEAST 18" ABOVE GRADE.
 - CONTRACTOR SHALL COORDINATE NEW ELECTRICAL SERVICE WITH UTILITY.
 - WETWELL IS CLASSIFIED HAZARDOUS, CLASS 1, DIVISION 1, GROUP D BY THE NEC. ALL CONDUITS ENTERING THIS AREA SHALL BE PROVIDED WITH SUITABLE SEAL OFFS OR AIR GAPS.
 - REMOVE EXISTING DISCONNECT SWITCH, MANUAL TRANSFER SWITCH, PANELBOARD, PUMP CONTROL PANEL, AND SCADA PANEL FROM EXISTING ELECTRICAL EQUIPMENT RACK ALONG WITH ALL ASSOCIATED CABLE AND CONDUIT. EXISTING LIGHT FIXTURE AND LIGHT SWITCH TO REMAIN. SEE SHEET E3 FOR RACK MODIFICATIONS.

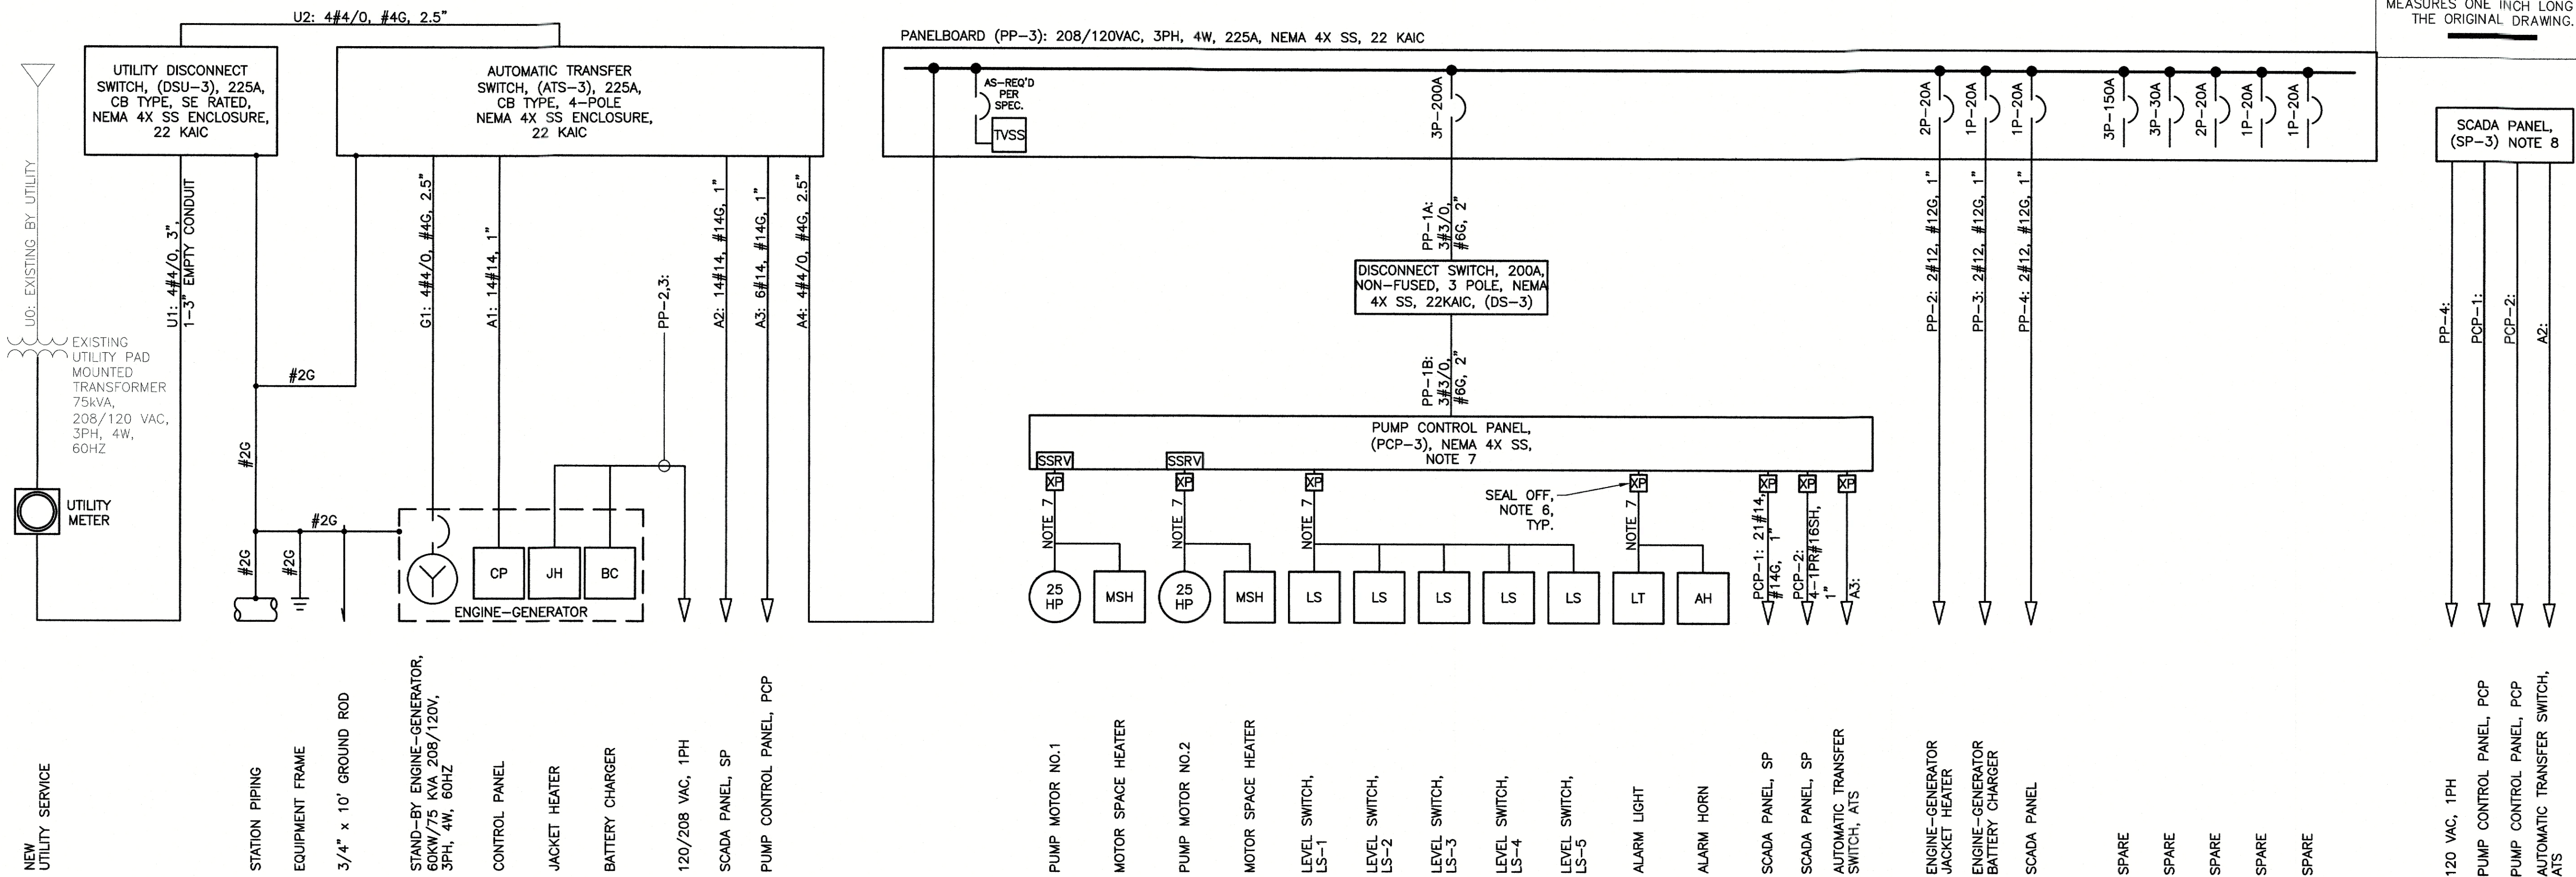


THE SCALE BAR SHOWN BELOW MEASURES ONE INCH LONG ON THE ORIGINAL DRAWING.

STURGILL ENGINEERING P.A.
ONE SOUTH MAIN ST.
LEXINGTON, NC 27292
(336) 238-1249 / PH.
(336) 236-6393 / FAX
C-1210

MOORE COUNTY PUBLIC WORKS

www.moorecountync.gov
5227 HWY 15-501
P.O. BOX 1927
CARTHAGE, NC 28327
(910) 947-6315

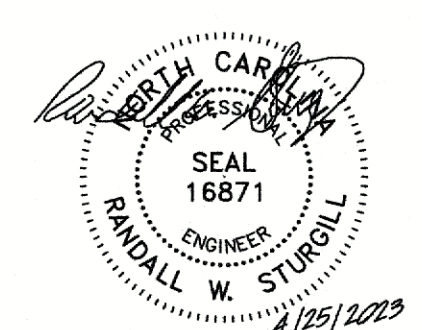

LIFT STATIONS 3-3 & 15-1 REPLACEMENT
PINEHURST, NC


DATE: APRIL 2023
DESIGNED BY:RWS
CADD BY: RWS

ELECTRICAL
ONE LINE DIAGRAM
LIFT STATION 3-3

NO.	DATE	BY	REVISIONS	DESCRIPTION

SHEET
E3

LIFT STATION 3-3 SYSTEM ONE-LINE DIAGRAM
NOT TO SCALE

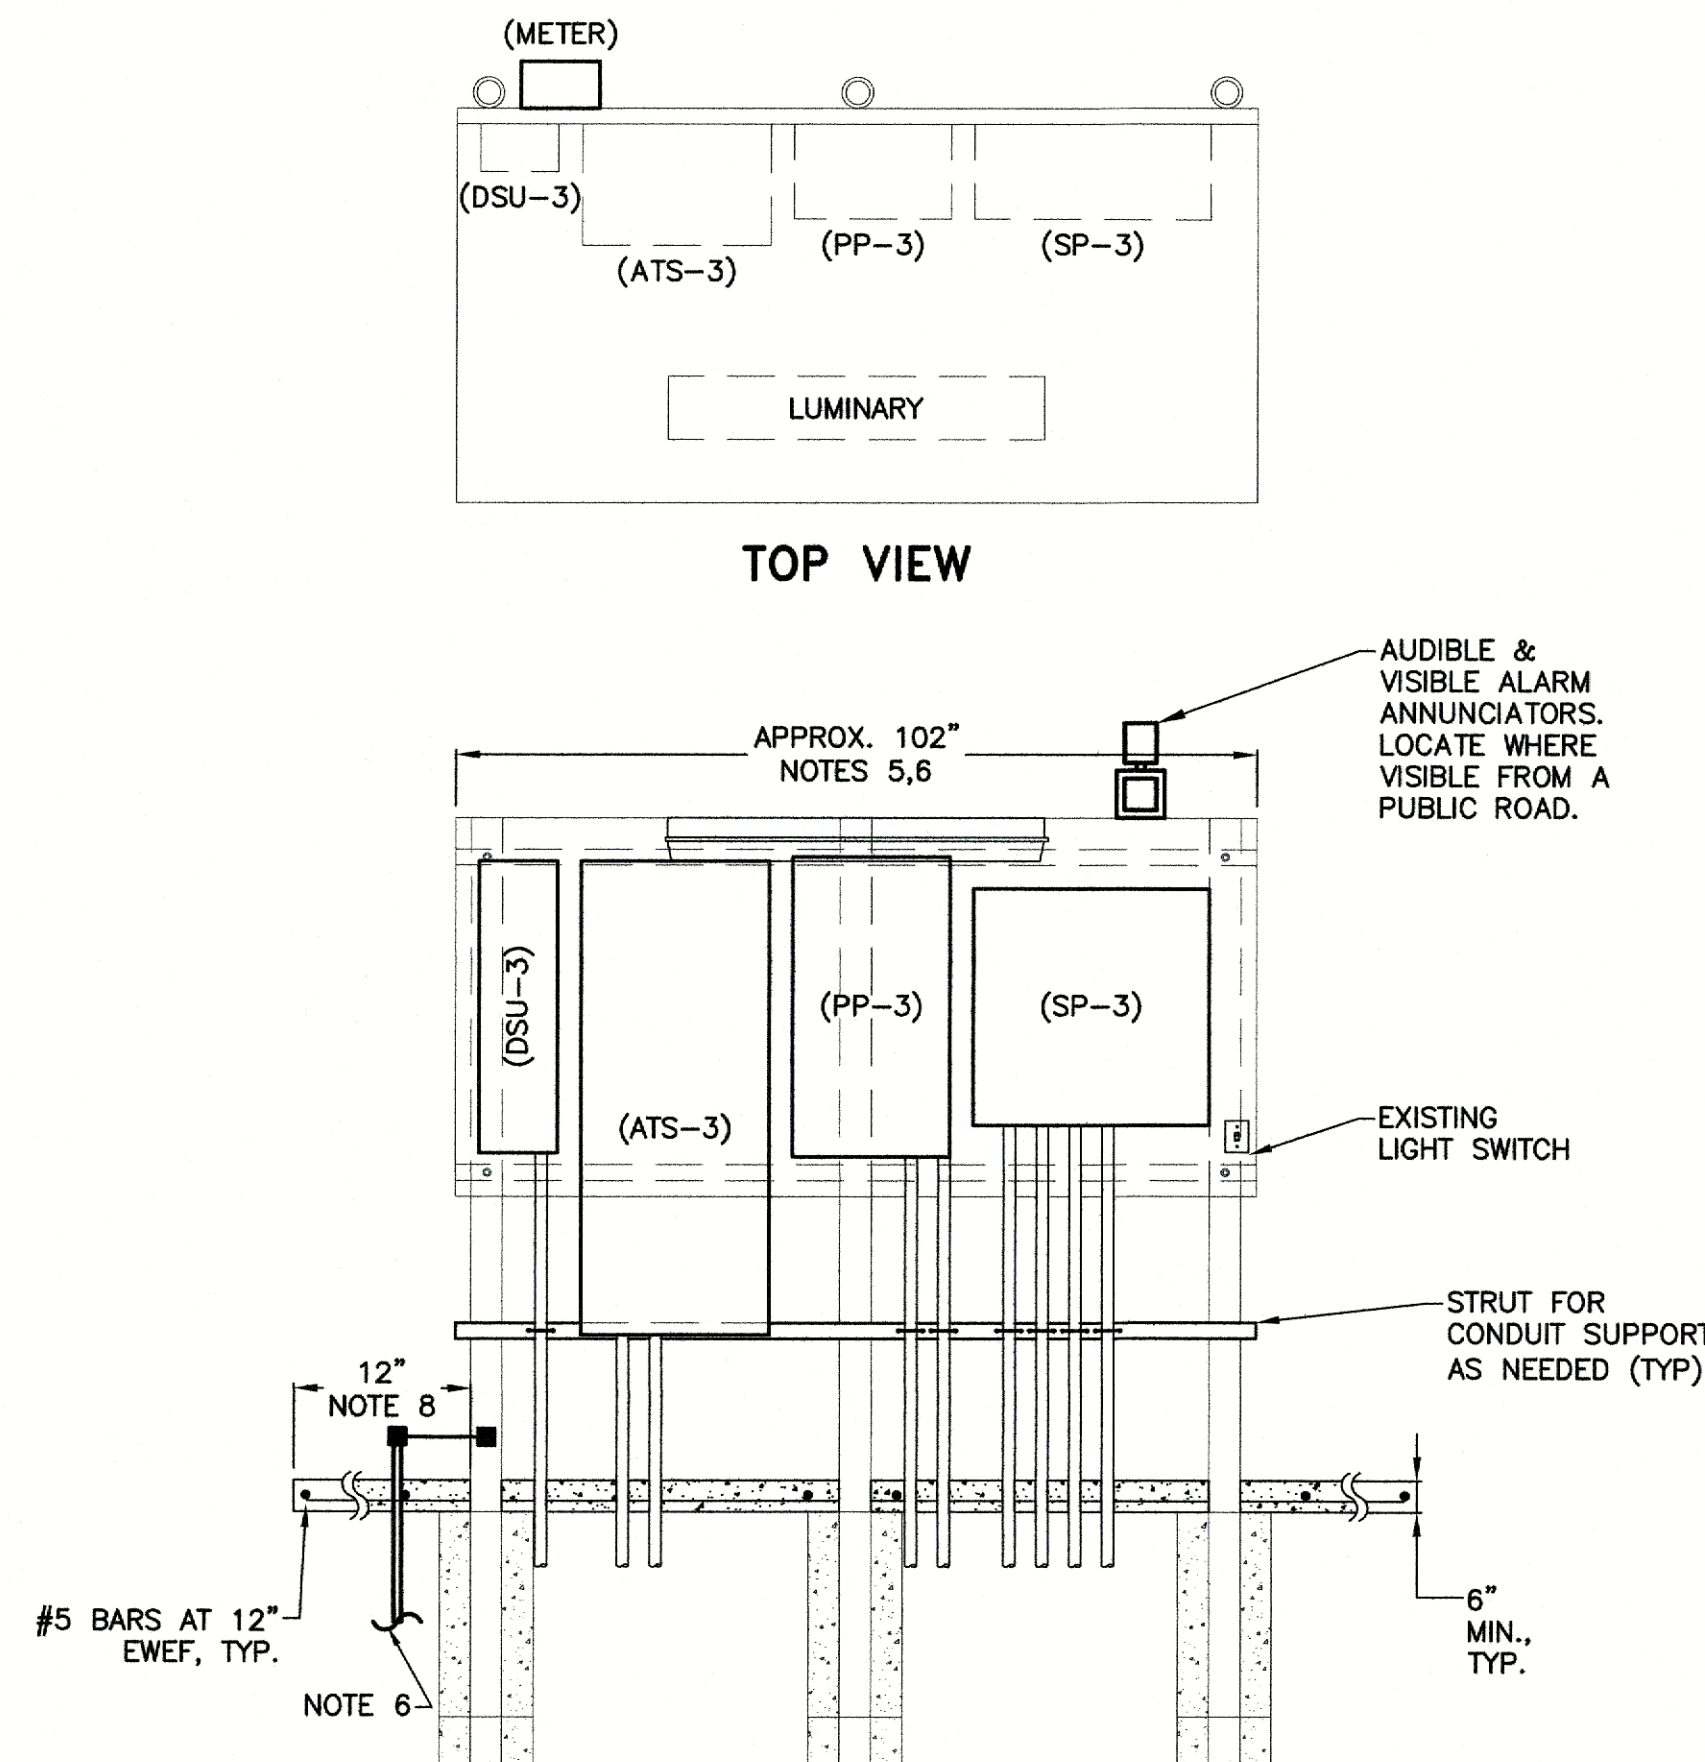


LIFT STATION 3-3 ELECTRICAL RACK DETAIL
NOT TO SCALE

ELECTRICAL EQUIPMENT RACK NOTES:


1. ELECTRICAL RACK, HOOD, LUMINARY, AND LIGHT SWITCH ARE EXISTING.
2. MODIFY RACK AS NEEDED TO INSTALL NEW EQUIPMENT.
3. PROVIDE NEW 6" CONCRETE PAD. EXTEND CONCRETE PAD 12" PAST EACH SIDE AND THE BACK OF THE RACK. EXTEND CONCRETE PAD AT LEAST 60" PAST FRONT FACE OF RACK.
4. CORROSION-RESISTANT COATING OF THIXOTROPIC COAL TAR PAINT SHALL BE APPLIED TO ALL CONDUITS THAT TURN OUT OF CONCRETE, MASONRY, OR EARTH. THE COATING SHALL CONSIST OF A HEAVY COAT OF COAL TAR PAINT EXTENDING SIX INCHES ON EACH SIDE OF THE POINT OF TURN-OUT.
5. ZINC RICH PAINT SHALL BE FIELD APPLIED TO ALL SAW CUTS, PIPE THREADS, FASTNER HARDWARE, AND DAMAGED FINISHES OF GALVANIZED MATERIALS.
6. 5/8" DIA. x 10' GROUND ROD, QTY. AS REQD. BY NEC & LAHJ.

NOTES:


1. SEE SHEET E1 FOR LEGEND, ABBREVIATIONS, GENERAL NOTES AND DETAILS.
2. CONTRACTOR SHALL COORDINATE ROUTING OF CONDUITS WITH OWNER AND OTHER TRADES.
3. CONTRACTOR SHALL VERIFY ALL EQUIPMENT LOCATIONS AND CONNECTION POINTS PRIOR TO INSTALLATION.
4. CONTRACTOR SHALL PROVIDE ALL LABOR, MATERIALS, TOOLS, EQUIPMENT, PERMITS, AND OPERATIONS NECESSARY FOR THE PROPER EXECUTION AND COMPLETION OF ALL ELECTRICAL WORK INDICATED ON THE DRAWINGS.
5. ALL ELECTRICAL WORK AND MATERIALS SHALL COMPLY WITH THE NEC AND OTHER APPLICABLE FEDERAL, STATE, AND LOCAL CODES. ALL ELECTRICAL EQUIPMENT SHALL BE THIRD PARTY LISTED OR LABELED.
6. WETWELL IS CLASSIFIED HAZARDOUS, CLASS 1, DIVISION 1 GROUP D BY THE NEC. ALL CONDUITS ENTERING THIS AREA SHALL BE PROVIDED WITH SUITABLE SEALS.
7. PUMP CONTROL PANEL, PUMPS, LEVEL SWITCHES, ETC. PROVIDED AS PACKAGED PUMP STATION. ALL ELECTRICAL EQUIPMENT COMES PRE-WIRED.
8. SCADA PANEL FURNISHED BY OTHERS, INSTALLED BY CONTRACTOR. INCLUDE PROVISIONS ON RACK FOR 24" HIGH x 24" WIDE x 12" DEEP PANEL. COORDINATE EXACT REQUIREMENTS PRIOR TO BUILDING RACK.

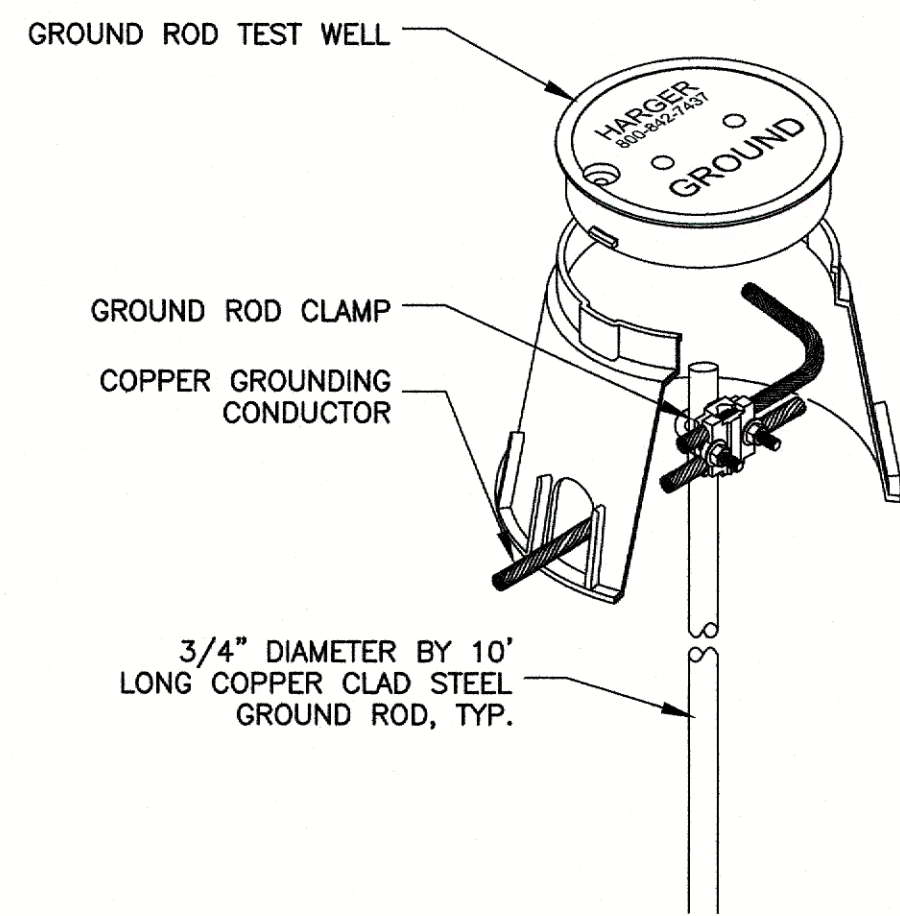


GROUND ROD TEST WELL DETAIL
SCALE: NOT TO SCALE

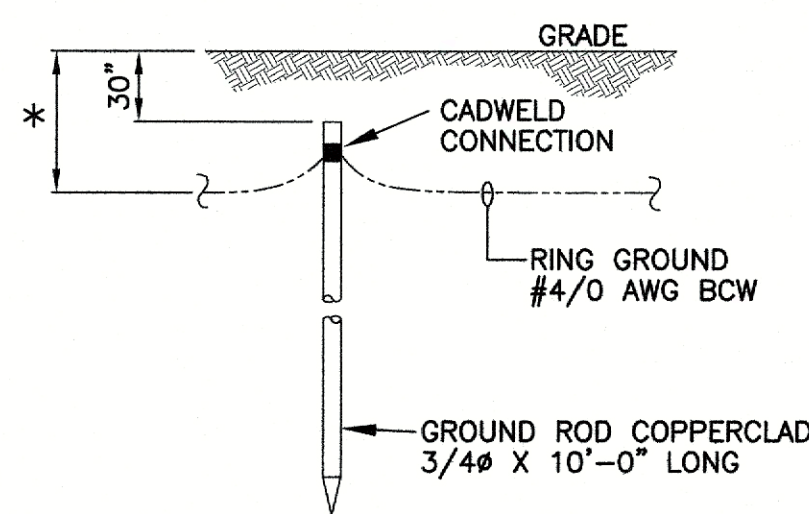


* 2'-6" OR 6" BELOW FROST LINE, WHICHEVER IS DEEPER
GROUND ROD DETAIL
SCALE: NOT TO SCALE

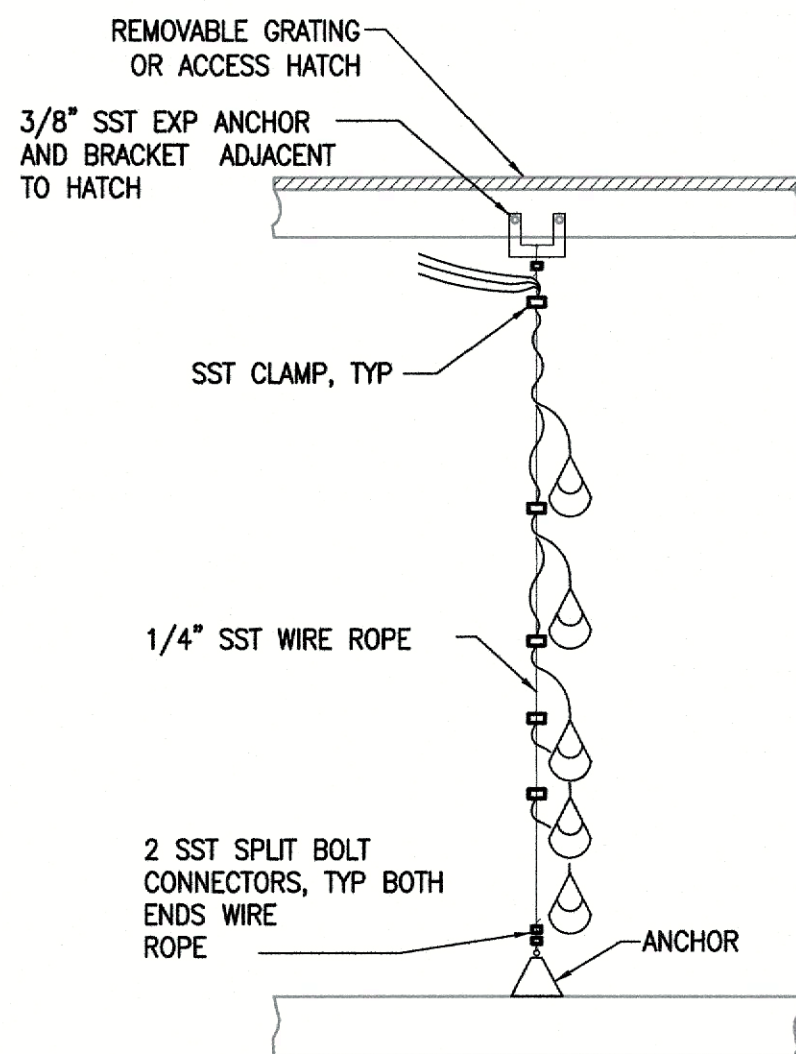

FLOAT SWITCH MOUNTING DETAIL
SCALE: NOT TO SCALE

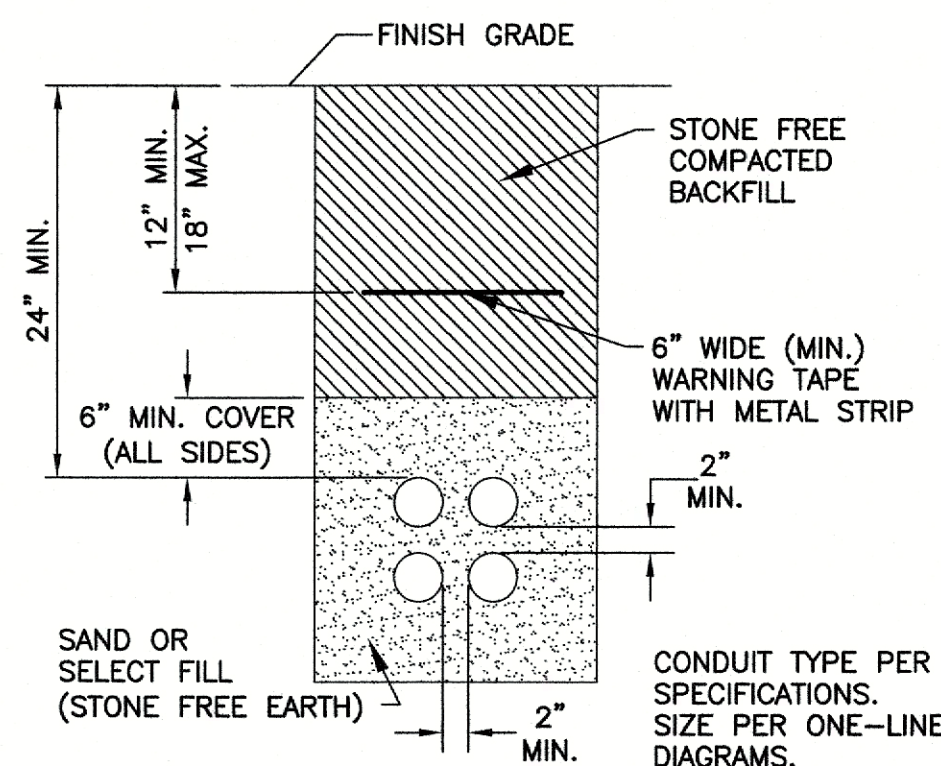


DIRECT BURIED CONDUIT DETAIL
SCALE: NOT TO SCALE

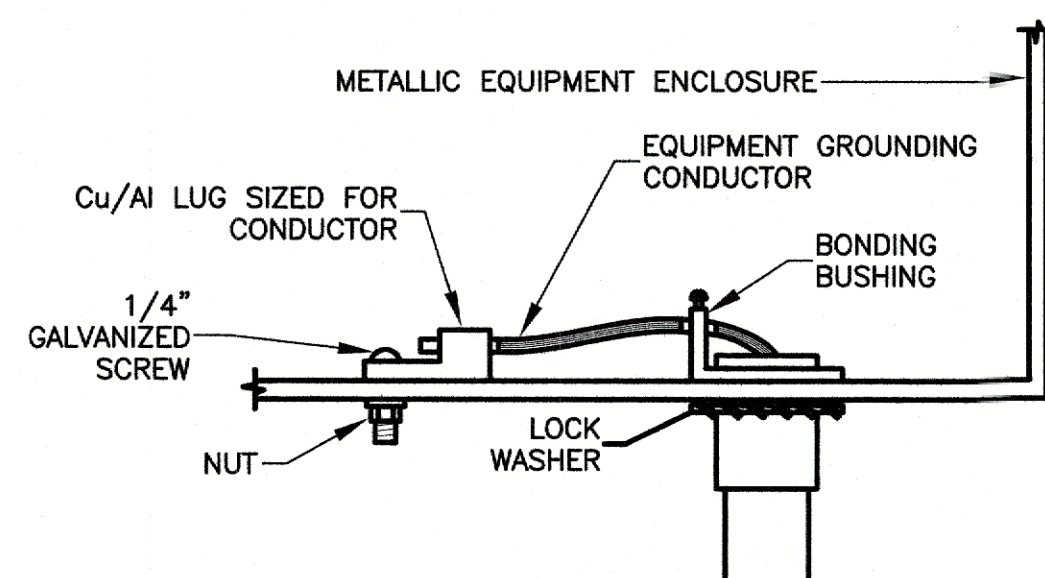

- NOTES:**
1. ONE CONDUCTOR PER LUG. USE MULTIPLE BARREL LUGS AS REQUIRED.
 2. SCRAPE PAINT FROM UNDER LUG TO ASSURE METAL CONTACT.

TYPICAL EQUIPMENT GROUNDING DETAIL
SCALE: NOT TO SCALE

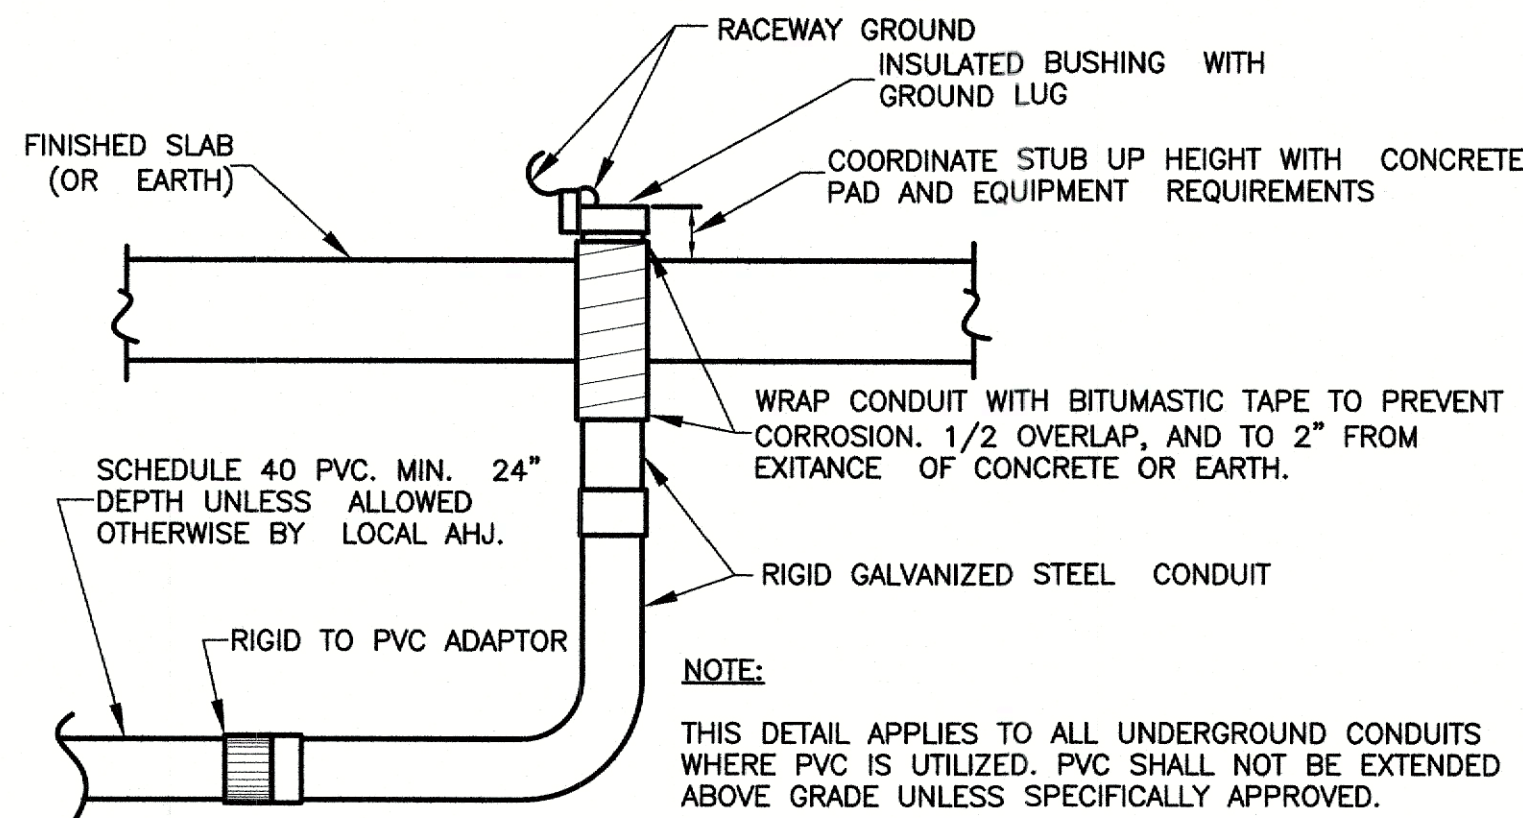

TYPICAL CONDUIT STUB UP DETAIL
SCALE: NOT TO SCALE

THE SCALE BAR SHOWN BELOW MEASURES ONE INCH LONG ON THE ORIGINAL DRAWING.


PANEL "A" 120/208V, 3ø, 4W, 225A
FED FROM MDP-21
INSTALLED 12/23/02

DISC AHU#1 120/208V, 3ø, 4W, 100A
FED FROM PP-2,4,6
INSTALLED 12/23/02



PANEL "AA" 120/208V, 3ø, 4W, 225A
SUB-FED FROM PNL "A"
INSTALLED 12/23/02

- NOTE:**
1. SUBMIT COMPLETE LIST OF PROPOSED NAMEPLATES TO ARCHITECT/ENGINEER FOR APPROVAL PRIOR TO FABRICATION.

TYPICAL NAMEPLATE DETAIL
SCALE: NOT TO SCALE

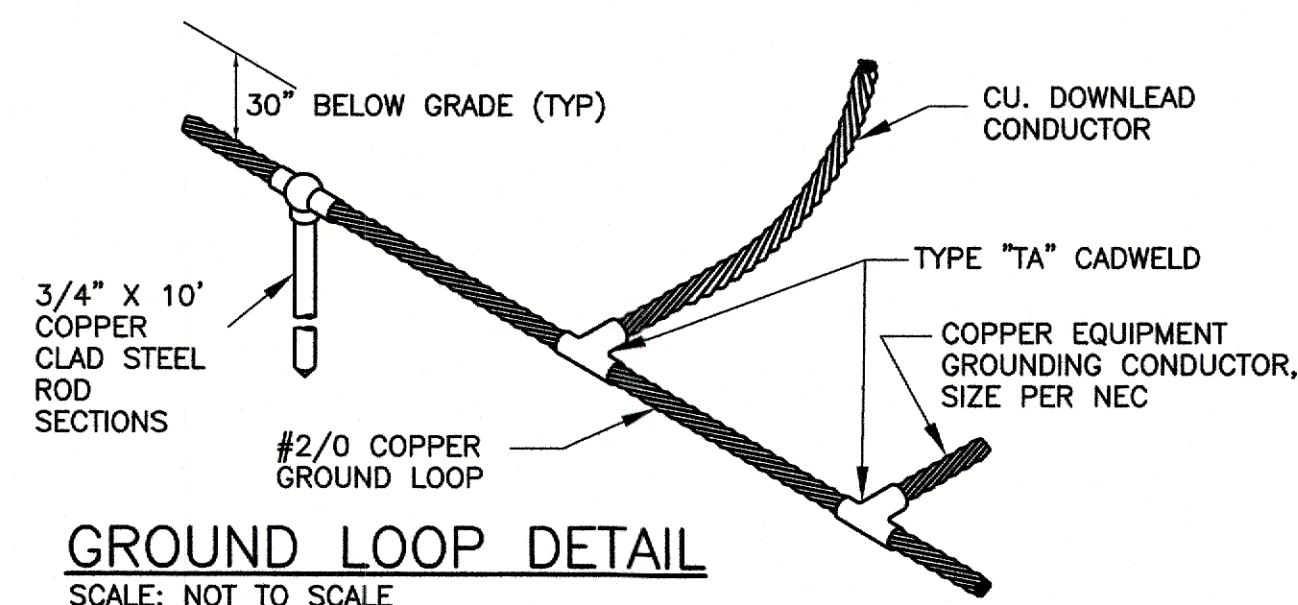

GROUND LOOP DETAIL
SCALE: NOT TO SCALE

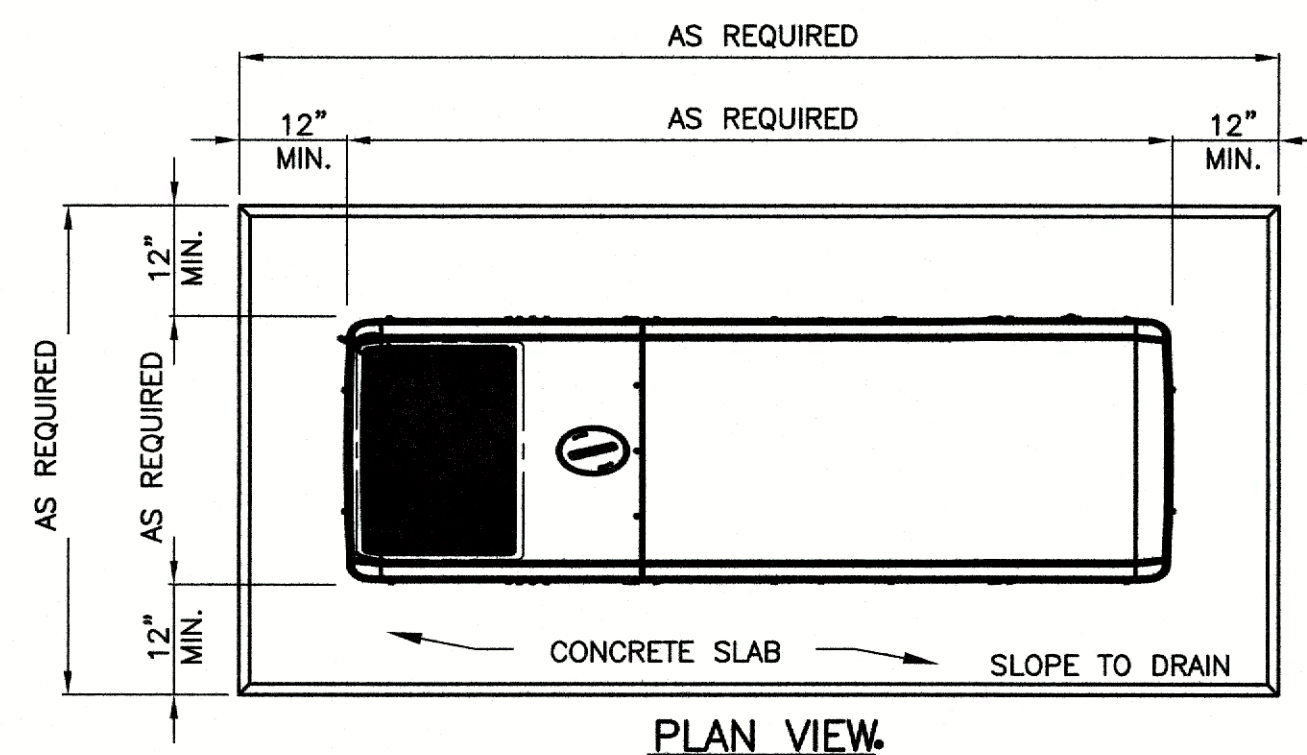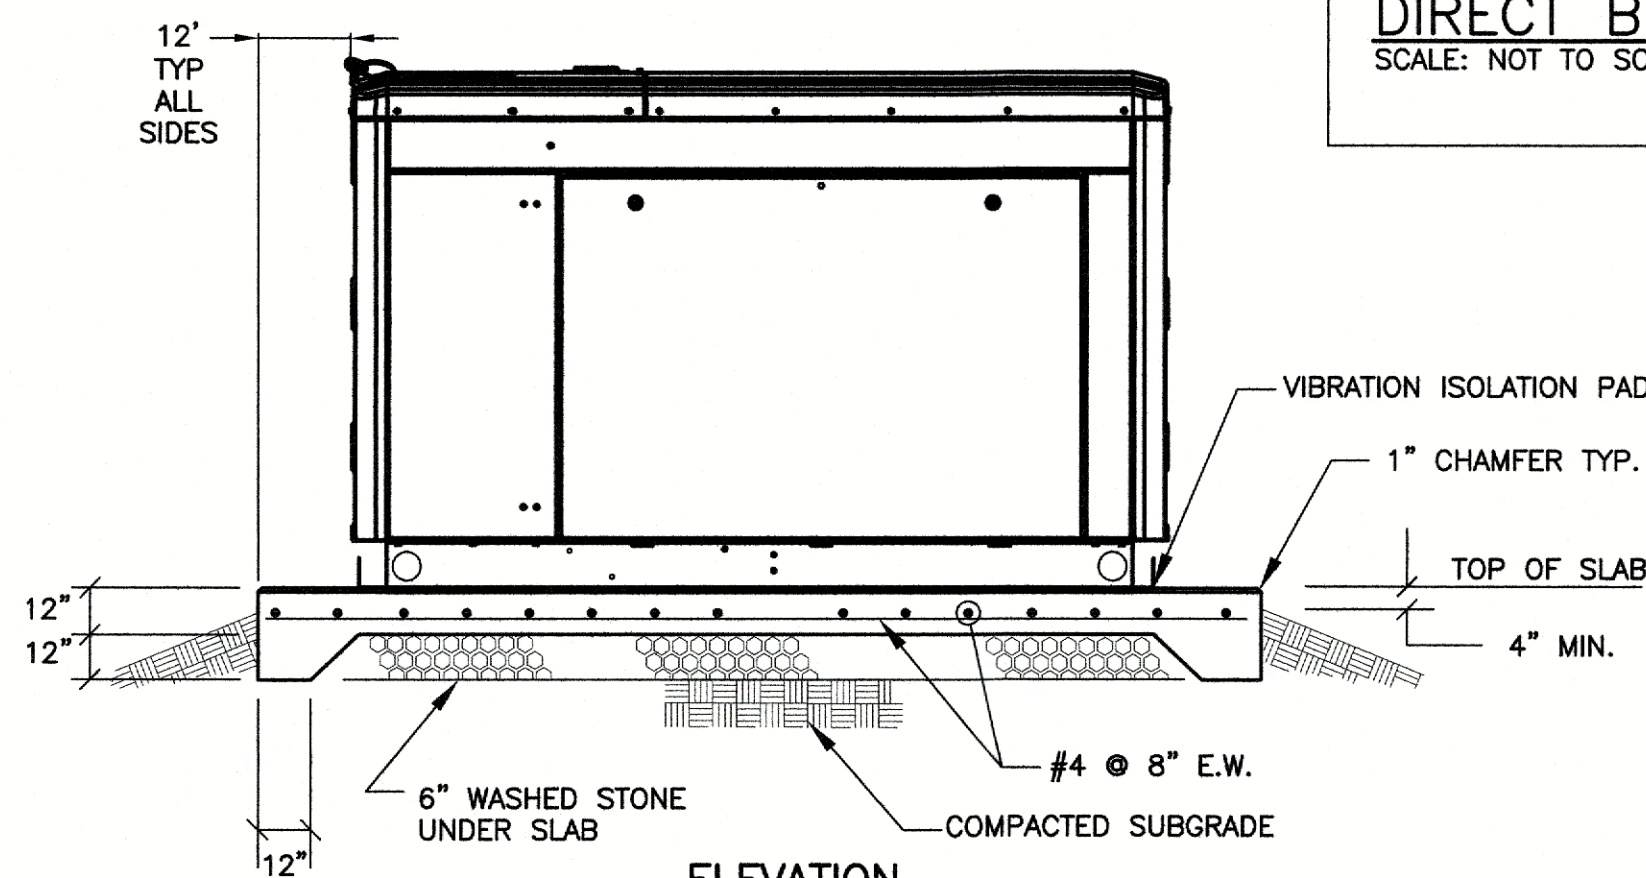

GENERATOR PAD DETAIL
SCALE: NOT TO SCALE

GENERATOR PAD NOTES:

1. THE SYSTEM SHALL BE COMPLETELY SELF CONTAINED. COMPLETE WITH GENERATOR SET, FUEL FEED LINES, STARTING BATTERIES AND CHARGER, AND ALL OTHER MISC. ITEMS TO FORM A COMPLETE AND OPERABLE SYSTEM.
2. DIMENSIONS MAY VARY DEPENDING UPON THE ACTUAL GENERATOR UNIT SUPPLIED.
3. GENERATOR TO BE ANCHOR BOLTED TO SLAB PER MANUFACTURER'S INSTRUCTIONS. VIBRATION ISOLATION PADS TO BE INSTALLED BETWEEN CONCRETE PAD & GENERATOR.
4. CONTRACTOR SHALL VERIFY PAD WITH ENGINE-GENERATOR SYSTEM SUPPLIER PRIOR TO POURING PAD.

STURGILL ENGINEERING P.A.
ONE SOUTH MAIN ST.
LEXINGTON, NC 27292
(336) 238-1249 PH.
(336) 236-6393 FAX

C-1210

MOORE COUNTY PUBLIC WORKS


www.moorecountync.gov

5227 HWY 15-501

P.O. BOX 1927

CARTHAGE, NC 28327

(910) 947-6315

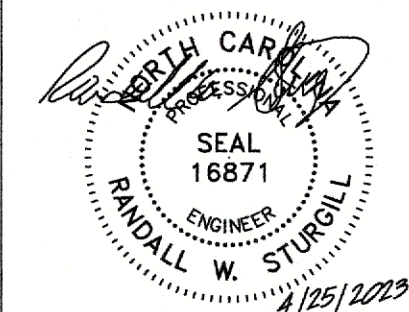

**LIFT STATIONS 3-3 & 15-1
REPLACEMENT**

PINEHURST, NC

DATE: APRIL 2023
DESIGNED BY:RWS
CADD BY: RWS

**ELECTRICAL
DETAILS**

NO. DATE BY DESCRIPTION

SHEET

E6